


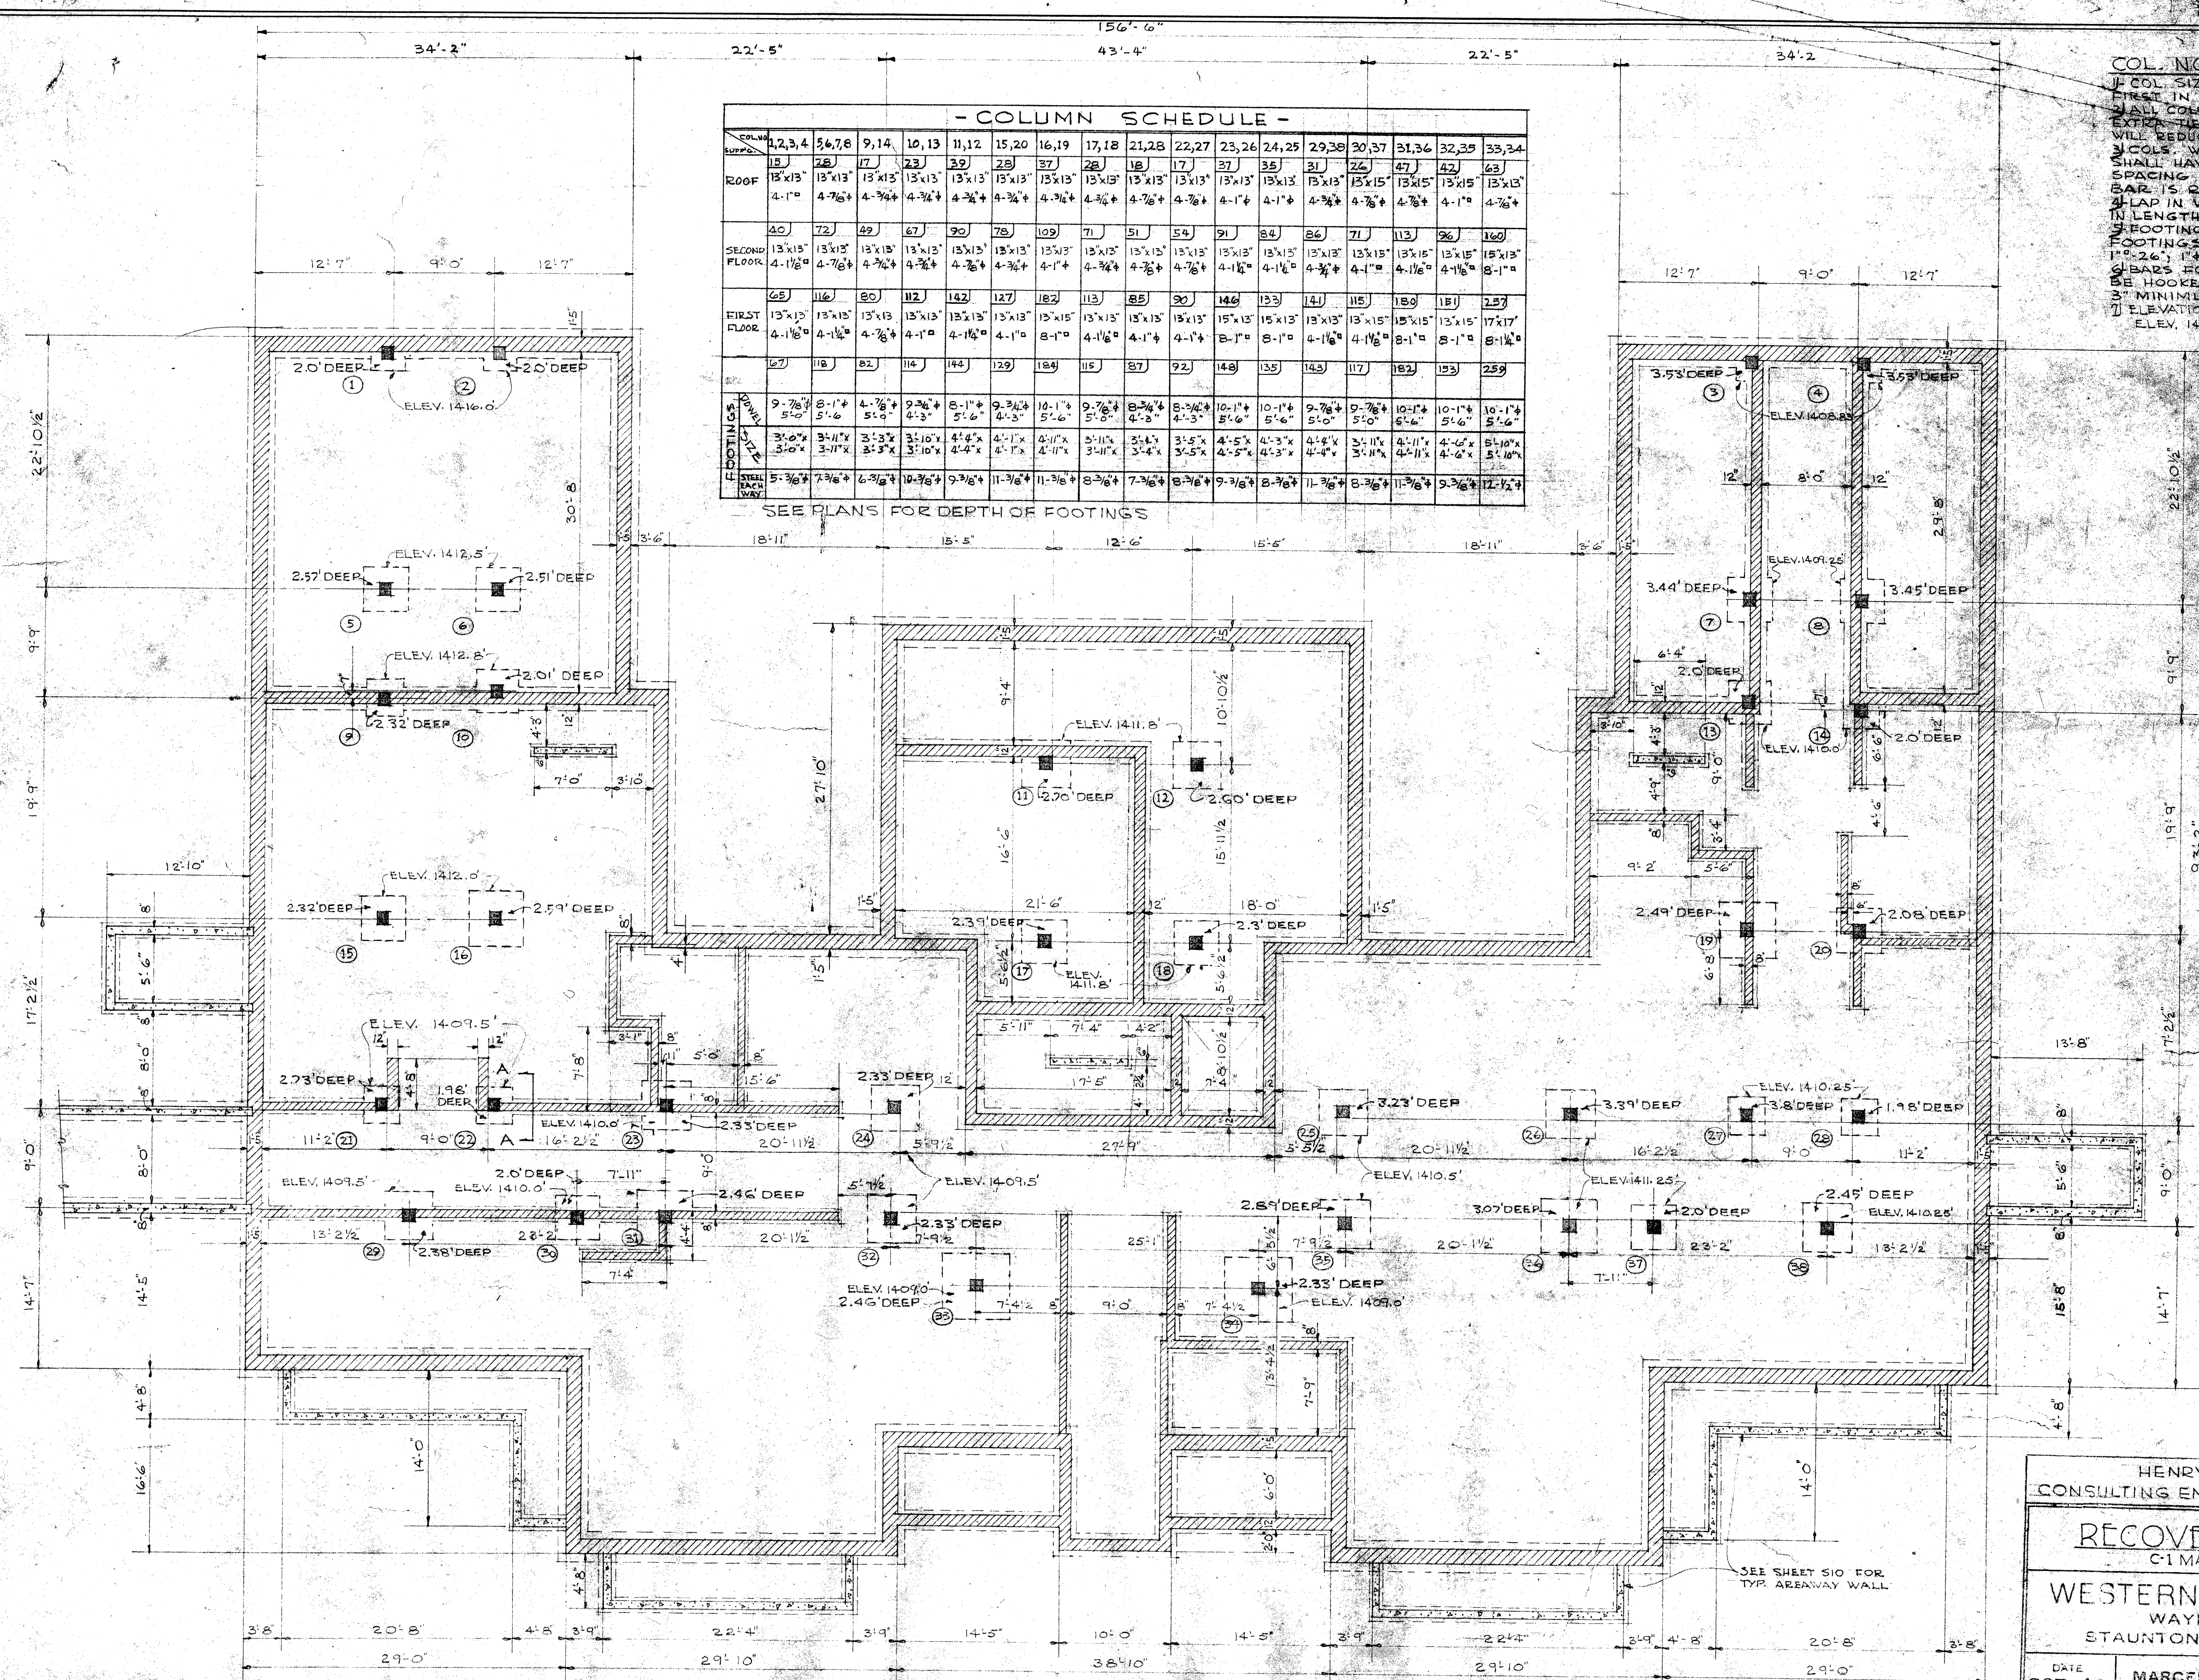


- COLUMN SCHEDULE -

COL. NO.	1,2,3,4	5,6,7,8	9,14	10,13	11,12	15,20	16,19	17,18	22,27	23,26	24,25	29,38	30,37	31,36	32,35	33,34
ROOF	13'x13'	13'x13'	13'x13'	13'x13'	13'x13'	13'x13'	13'x13'	13'x13'	13'x13'	13'x13'	13'x13'	13'x13'	13'x13'	13'x13'	13'x13'	13'x13'
SECOND FLOOR	13'x13'	13'x13'	13'x13'	13'x13'	13'x13'	13'x13'	13'x13'	13'x13'	13'x13'	13'x13'	13'x13'	13'x13'	13'x13'	13'x13'	13'x13'	13'x13'
FIRST FLOOR	13'x13'	13'x13'	13'x13'	13'x13'	13'x13'	13'x13'	13'x13'	13'x13'	13'x13'	13'x13'	13'x13'	13'x13'	13'x13'	13'x13'	13'x13'	13'x13'
FOOTING	4'-11"	4'-11"	4'-11"	4'-11"	4'-11"	4'-11"	4'-11"	4'-11"	4'-11"	4'-11"	4'-11"	4'-11"	4'-11"	4'-11"	4'-11"	4'-11"

SEE PLANS FOR DEPTH OF FOOTINGS

COL. NOTES:
 1. COL. SIZES IN THIS DIRECTION GIVEN FIRST IN SCHEDULE.
 2. ALL COLS. TO HAVE 1/4" TIES AT 12" PLUS AN EXTRA TIE AT TOP AND BOTTOM WHICH WILL REDUCE THE TWO END SPACES TO 6".
 3. COLS. WITH MORE THAN 4 FEET BARS SHALL HAVE ADDITIONAL SETS OF TIES AT SPACING NOTED SO THAT EACH VERTICAL BAR IS RESTRAINED AT A 90° BEND IN THE LAP IN VERT. COL. BARS SHALL BE 32 DIAM. IN LENGTH.
 4. FOOTING DOVELS SHALL PROJECT INTO FOOTINGS THE FOLLOWING DISTANCES:
 1" 26"; 14" 26"; 7/8" 23"; 3/4" 19"; 5/8" 16"; 6 BARS FOR REINFORCING FOOTINGS SHALL BE HOOKED EACH END AND SHALL HAVE A 3" MINIMUM CONCRETE COVERAGE.
 5. ELEVATION OF TOP OF COL. FTGS. SHOWN ELEV. 14.00.
 6. UNLESS OTHERWISE NOTED, ALL WALL FTGS. TO BE 12" WIDER THAN WALL ABOVE & 12" DEEP.

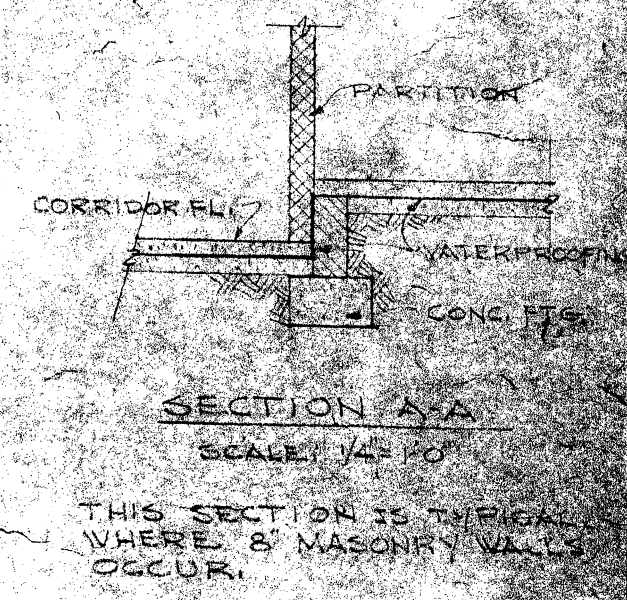

FOUNDATION PLAN
 BUILDING C1 FEMALE
 SCALE: 1/8" = 1'-0"



HENRY W. ROBERTS
 CONSULTING ENGR. STRUCTURAL DESIGN

RECOVERY BUILDINGS
 C1 MALE & C1 FEMALE

WESTERN STATE HOSPITAL
 WAYNESSBORO ROAD
 STAUNTON VIRGINIA

DATE OCT. 49	MARCELLUS WRIGHT & SON ARCHITECTS 1103 EAST MAIN STREET RICHMOND, VIRGINIA	SHEET 1 OF 16
-----------------	---	---------------------

B-101 & B-102

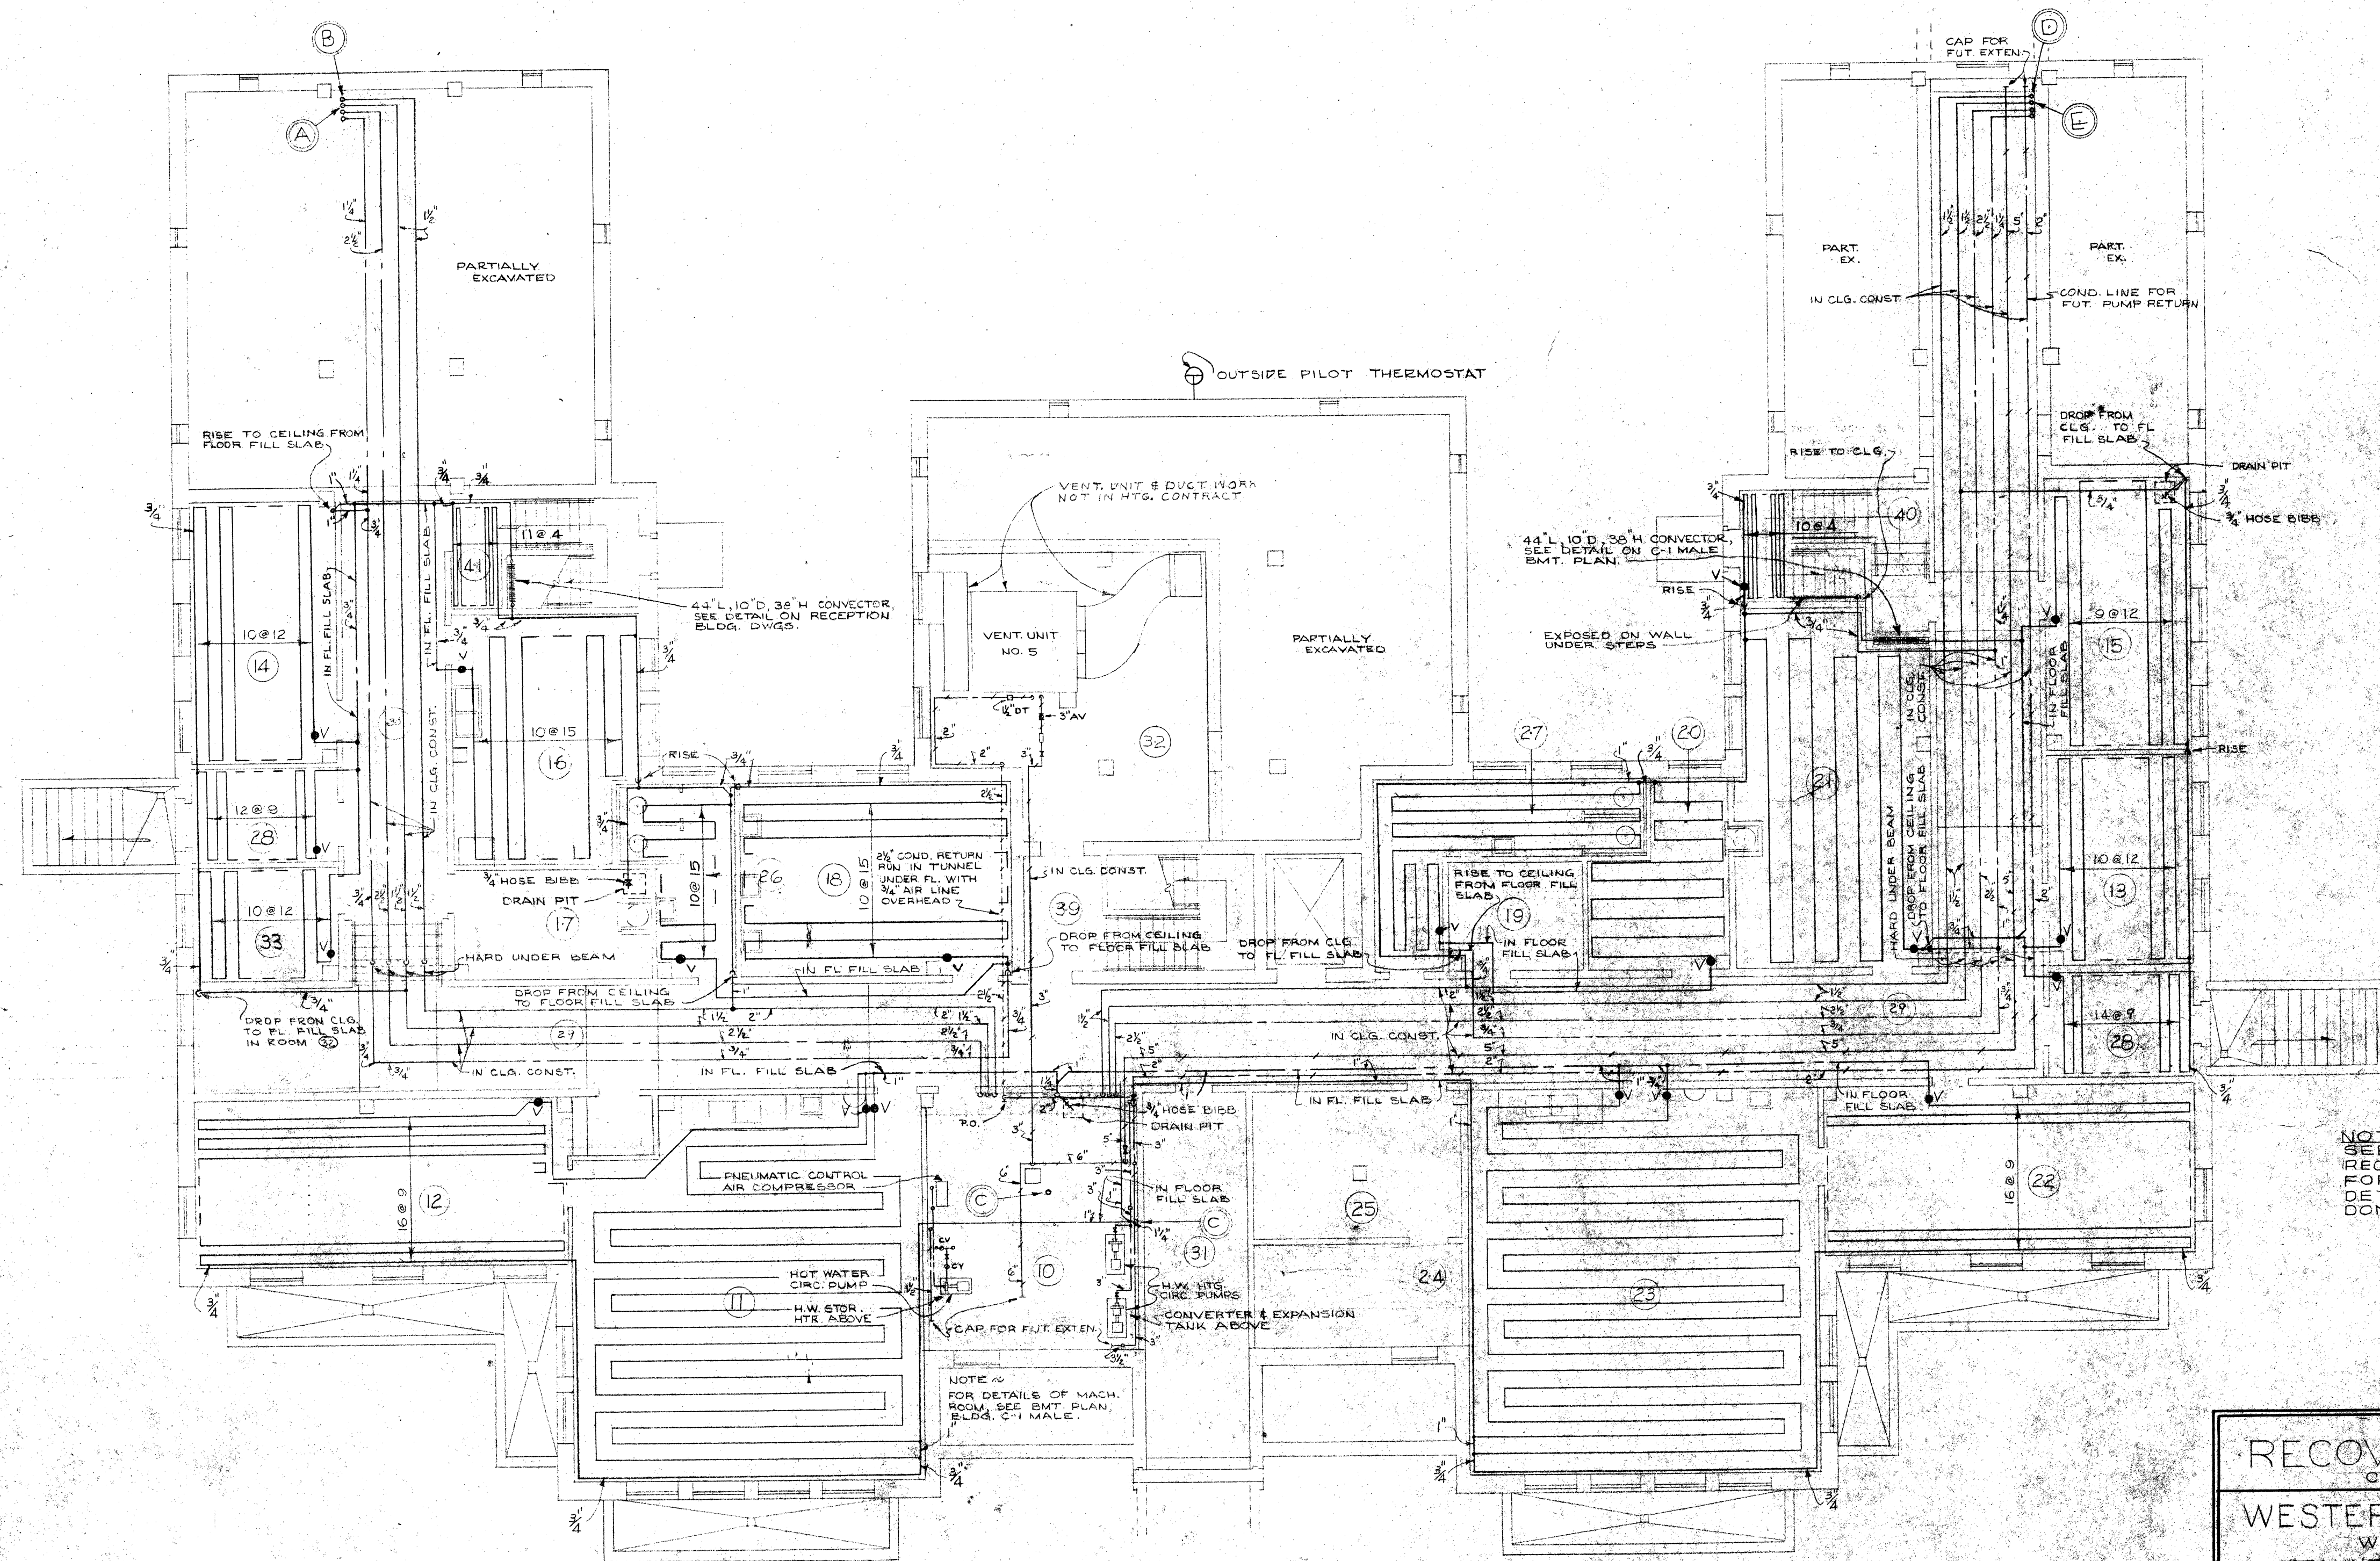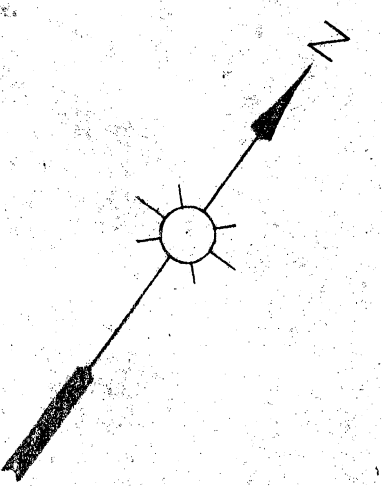


NOTE
SEE ALSO DETAILS @ ON
RECEPTION BLDG. DRAWINGS
FOR FURTHER TYPICAL
DETAILS ON WORK TO BE
DONE IN RECOVERY BLDGS.


HEATING

BASEMENT PLAN
BUILDING C-1 FEMALE
SCALE: 1/8" = 1'-0"

RECOVERY BUILDINGS
C-1 MALE / C-1 FEMALE
WESTERN STATE HOSPITAL
WAYNESBORO ROAD
STAUNTON VIRGINIA

HANKINS, TRAPNELL AND ANDERSON CONSULTING ENGINEERS RICHMOND, VIRGINIA	DATE OCT. 1949	MARCELLUS WRIGHT & SON ARCHITECTS 1005 EAST MAIN STREET RICHMOND, VIRGINIA	SHEET M-2 OF 12
	REVISED AUG. 1950 (AS BUILT)		

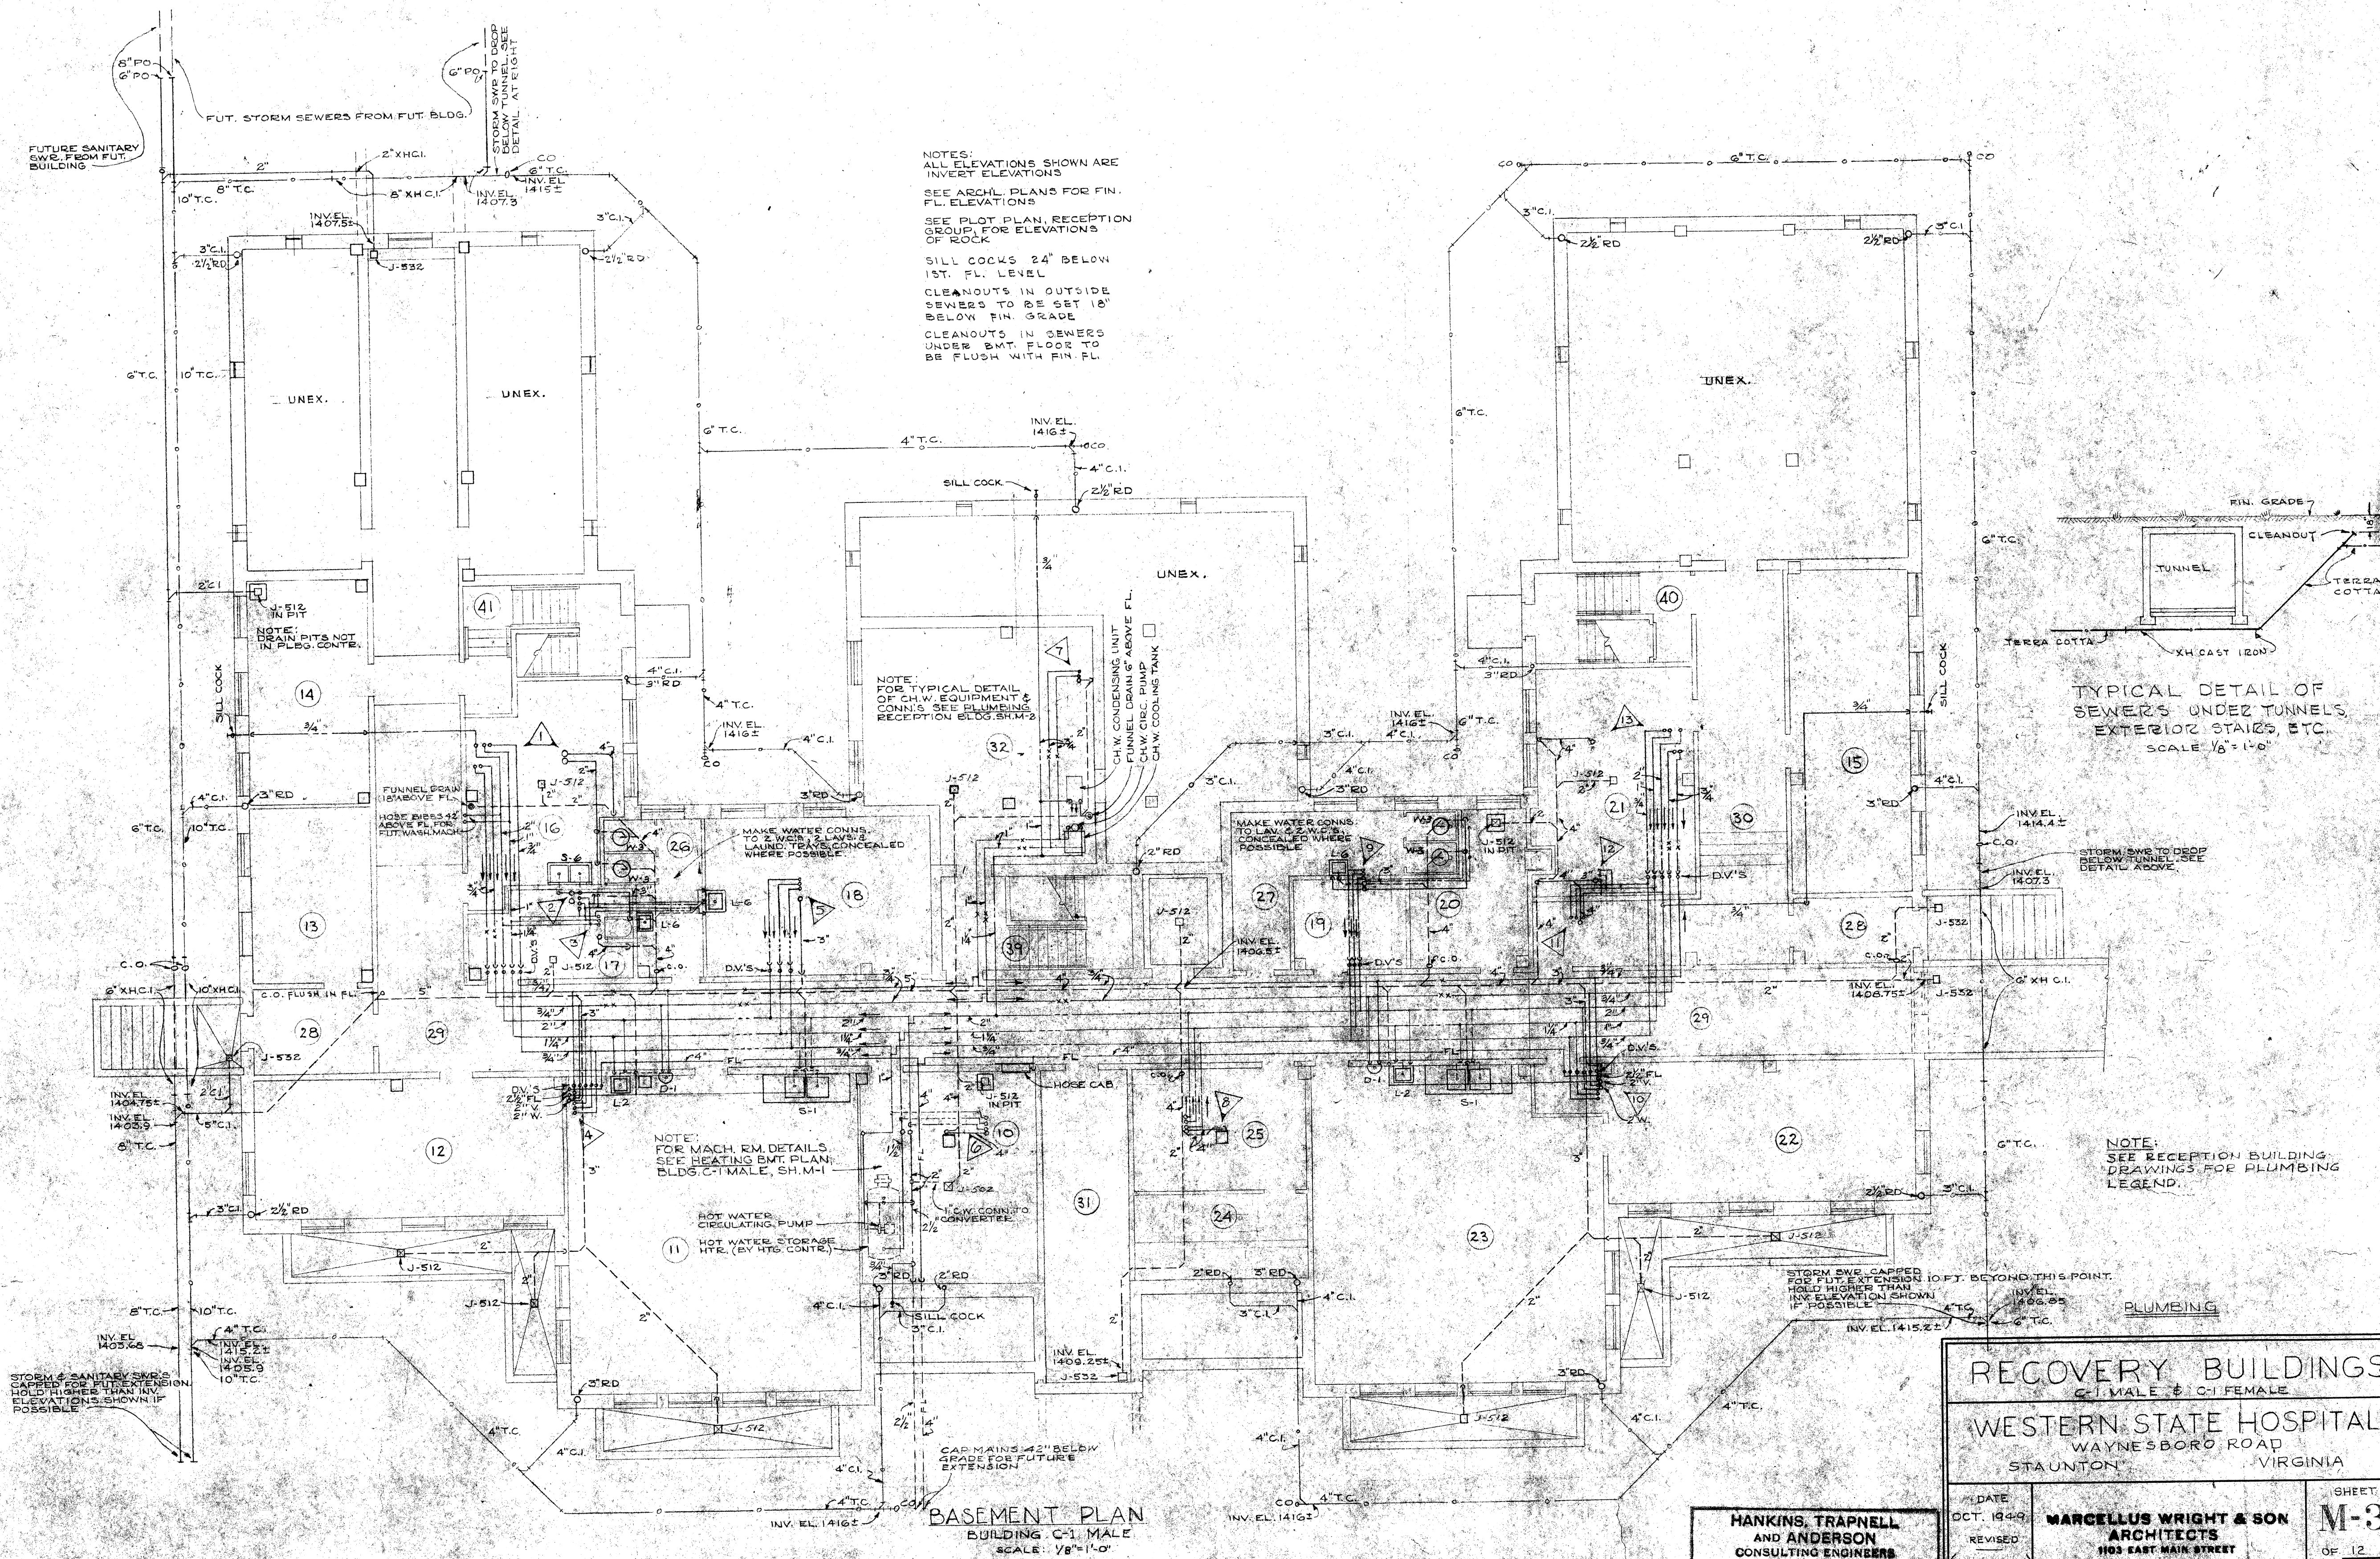

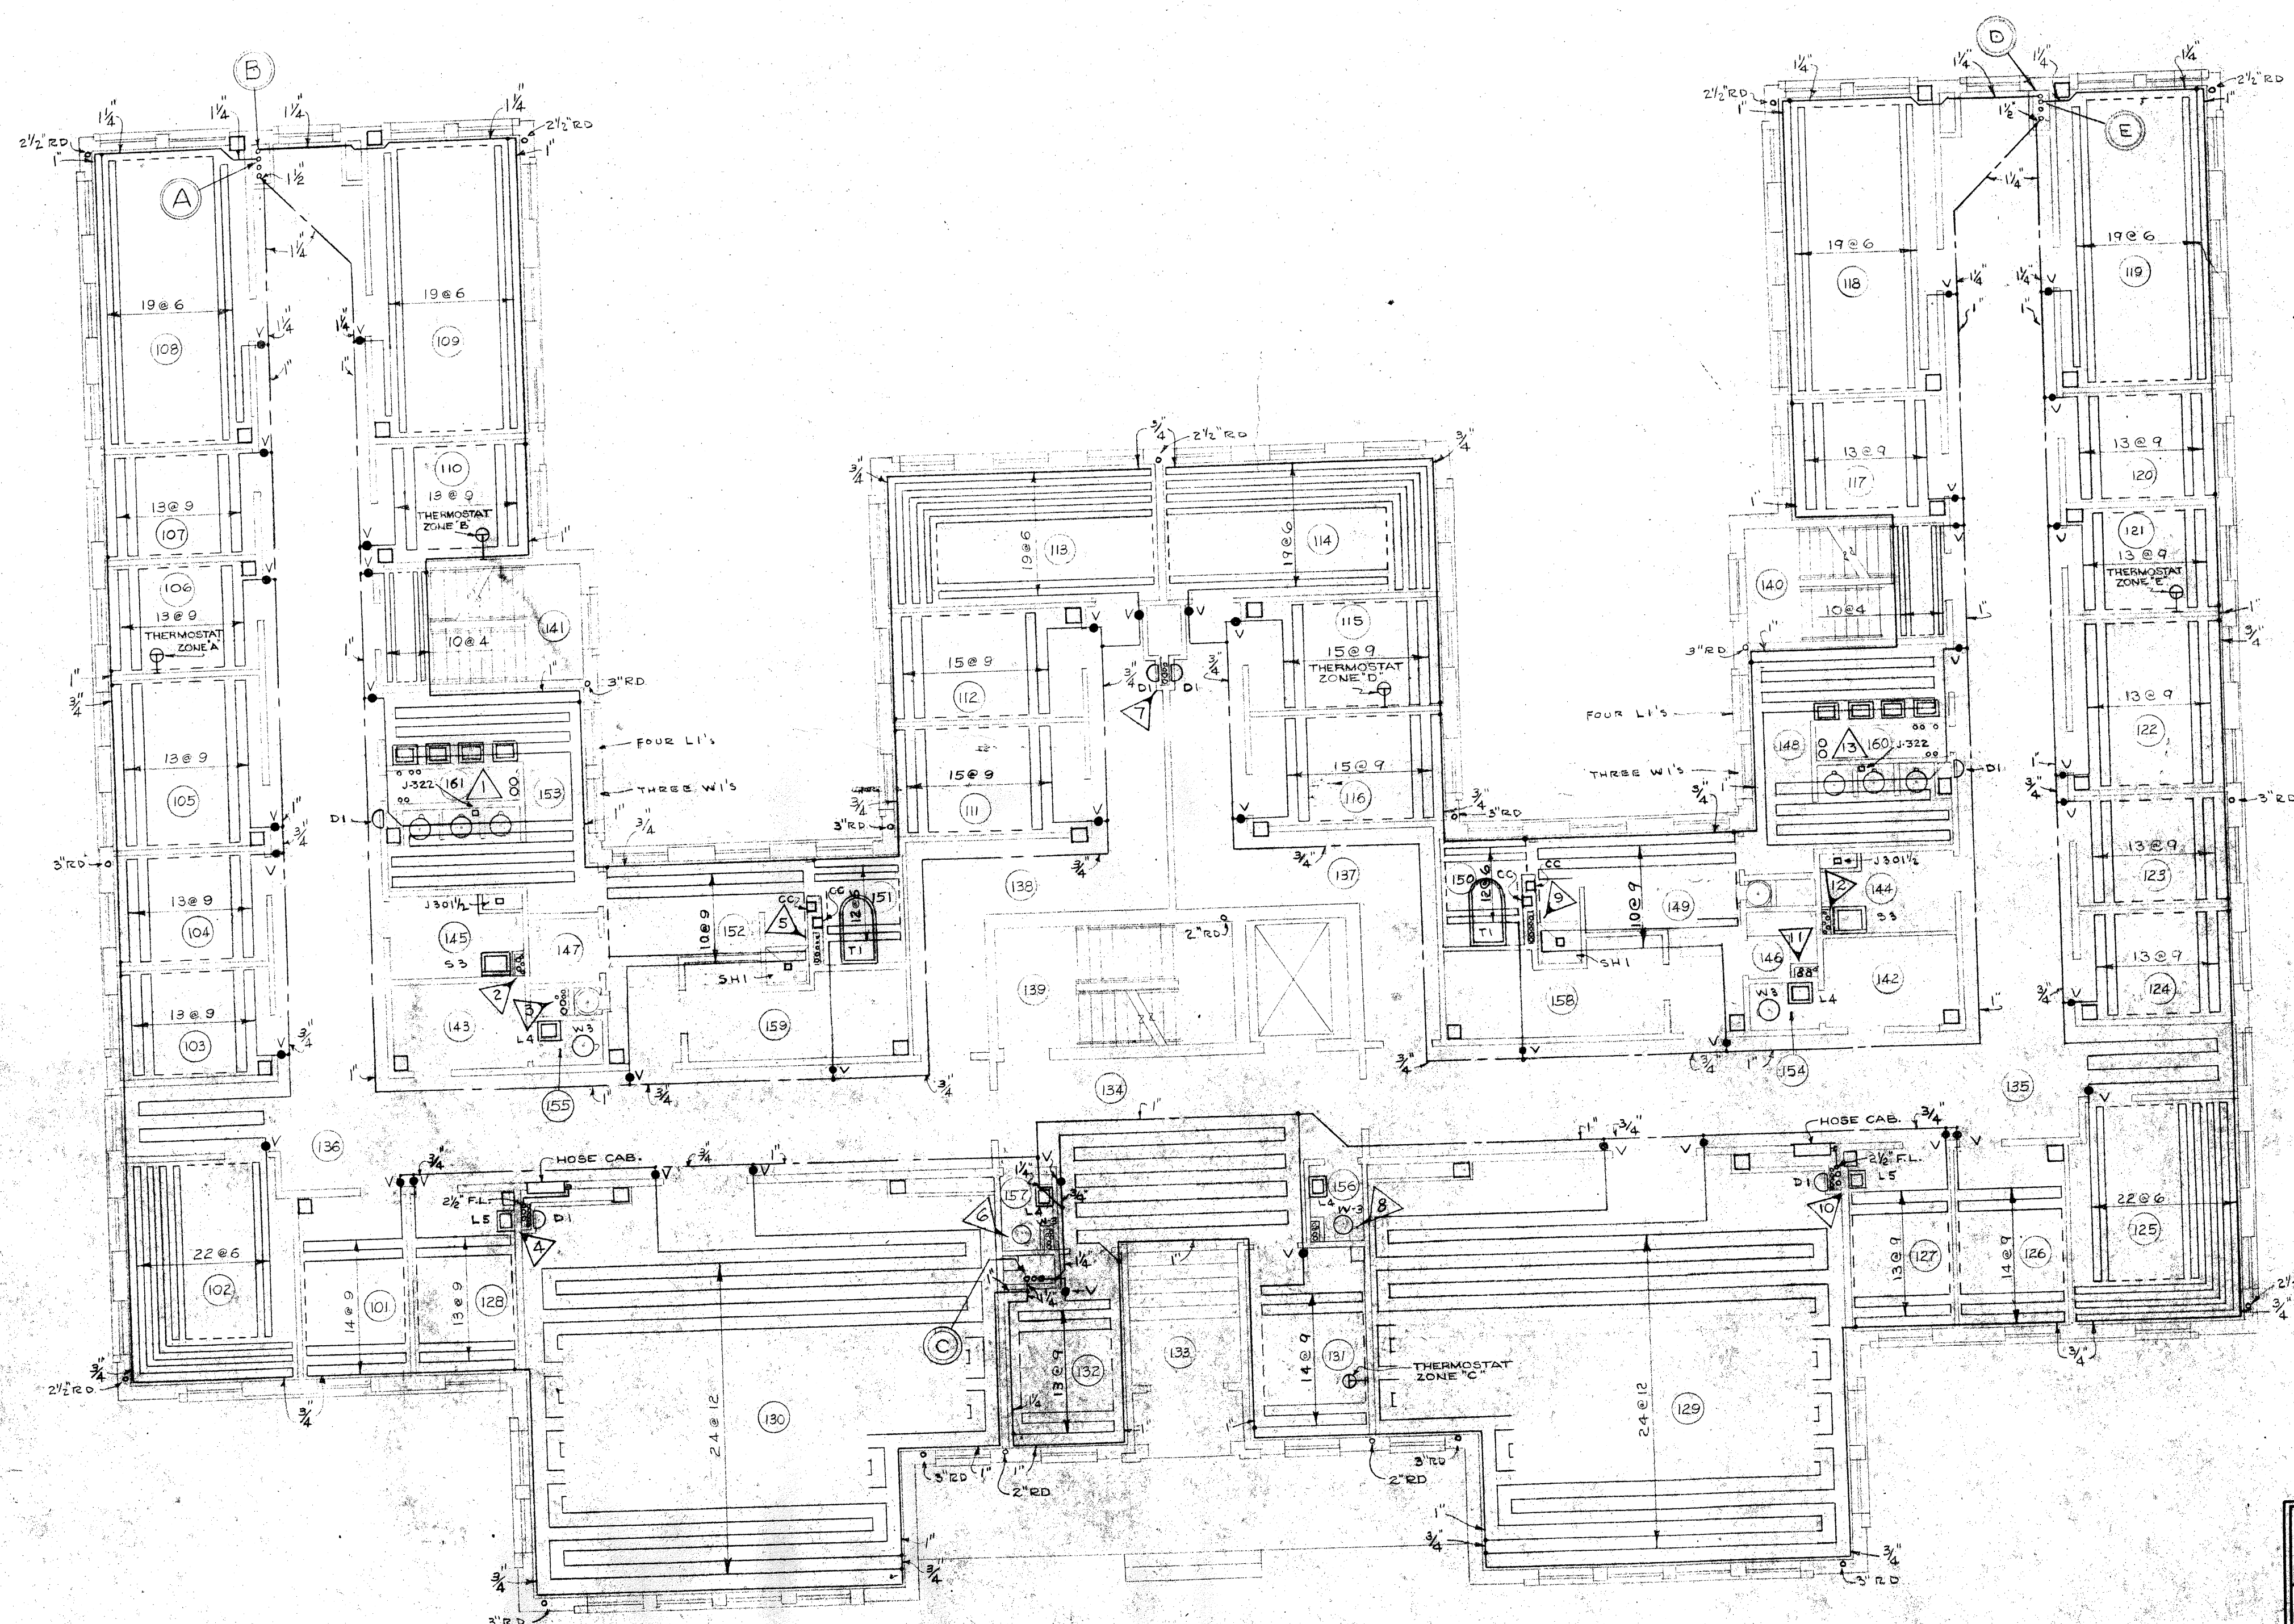


FIRST FLOOR PLAN
SCALE: 1/8" = 1'-0"

HEATING & PLUMBING

RECOVERY BUILDINGS CH. MALE & CH. FEMALE	
WESTERN STATE HOSPITAL WAYNESSBORO ROAD STAUNTON VIRGINIA	
DATE OCT. 1949 REVISED AUG. 1952 (AS BUILT)	MARCELLUS WRIGHT & SON ARCHITECTS 103 EAST MAIN STREET RICHMOND, VIRGINIA
SHEET M-5 OF 12	

HANKINS, TRAPNELL
AND ANDERSON
CONSULTING ENGINEERS
RICHMOND, VIRGINIA

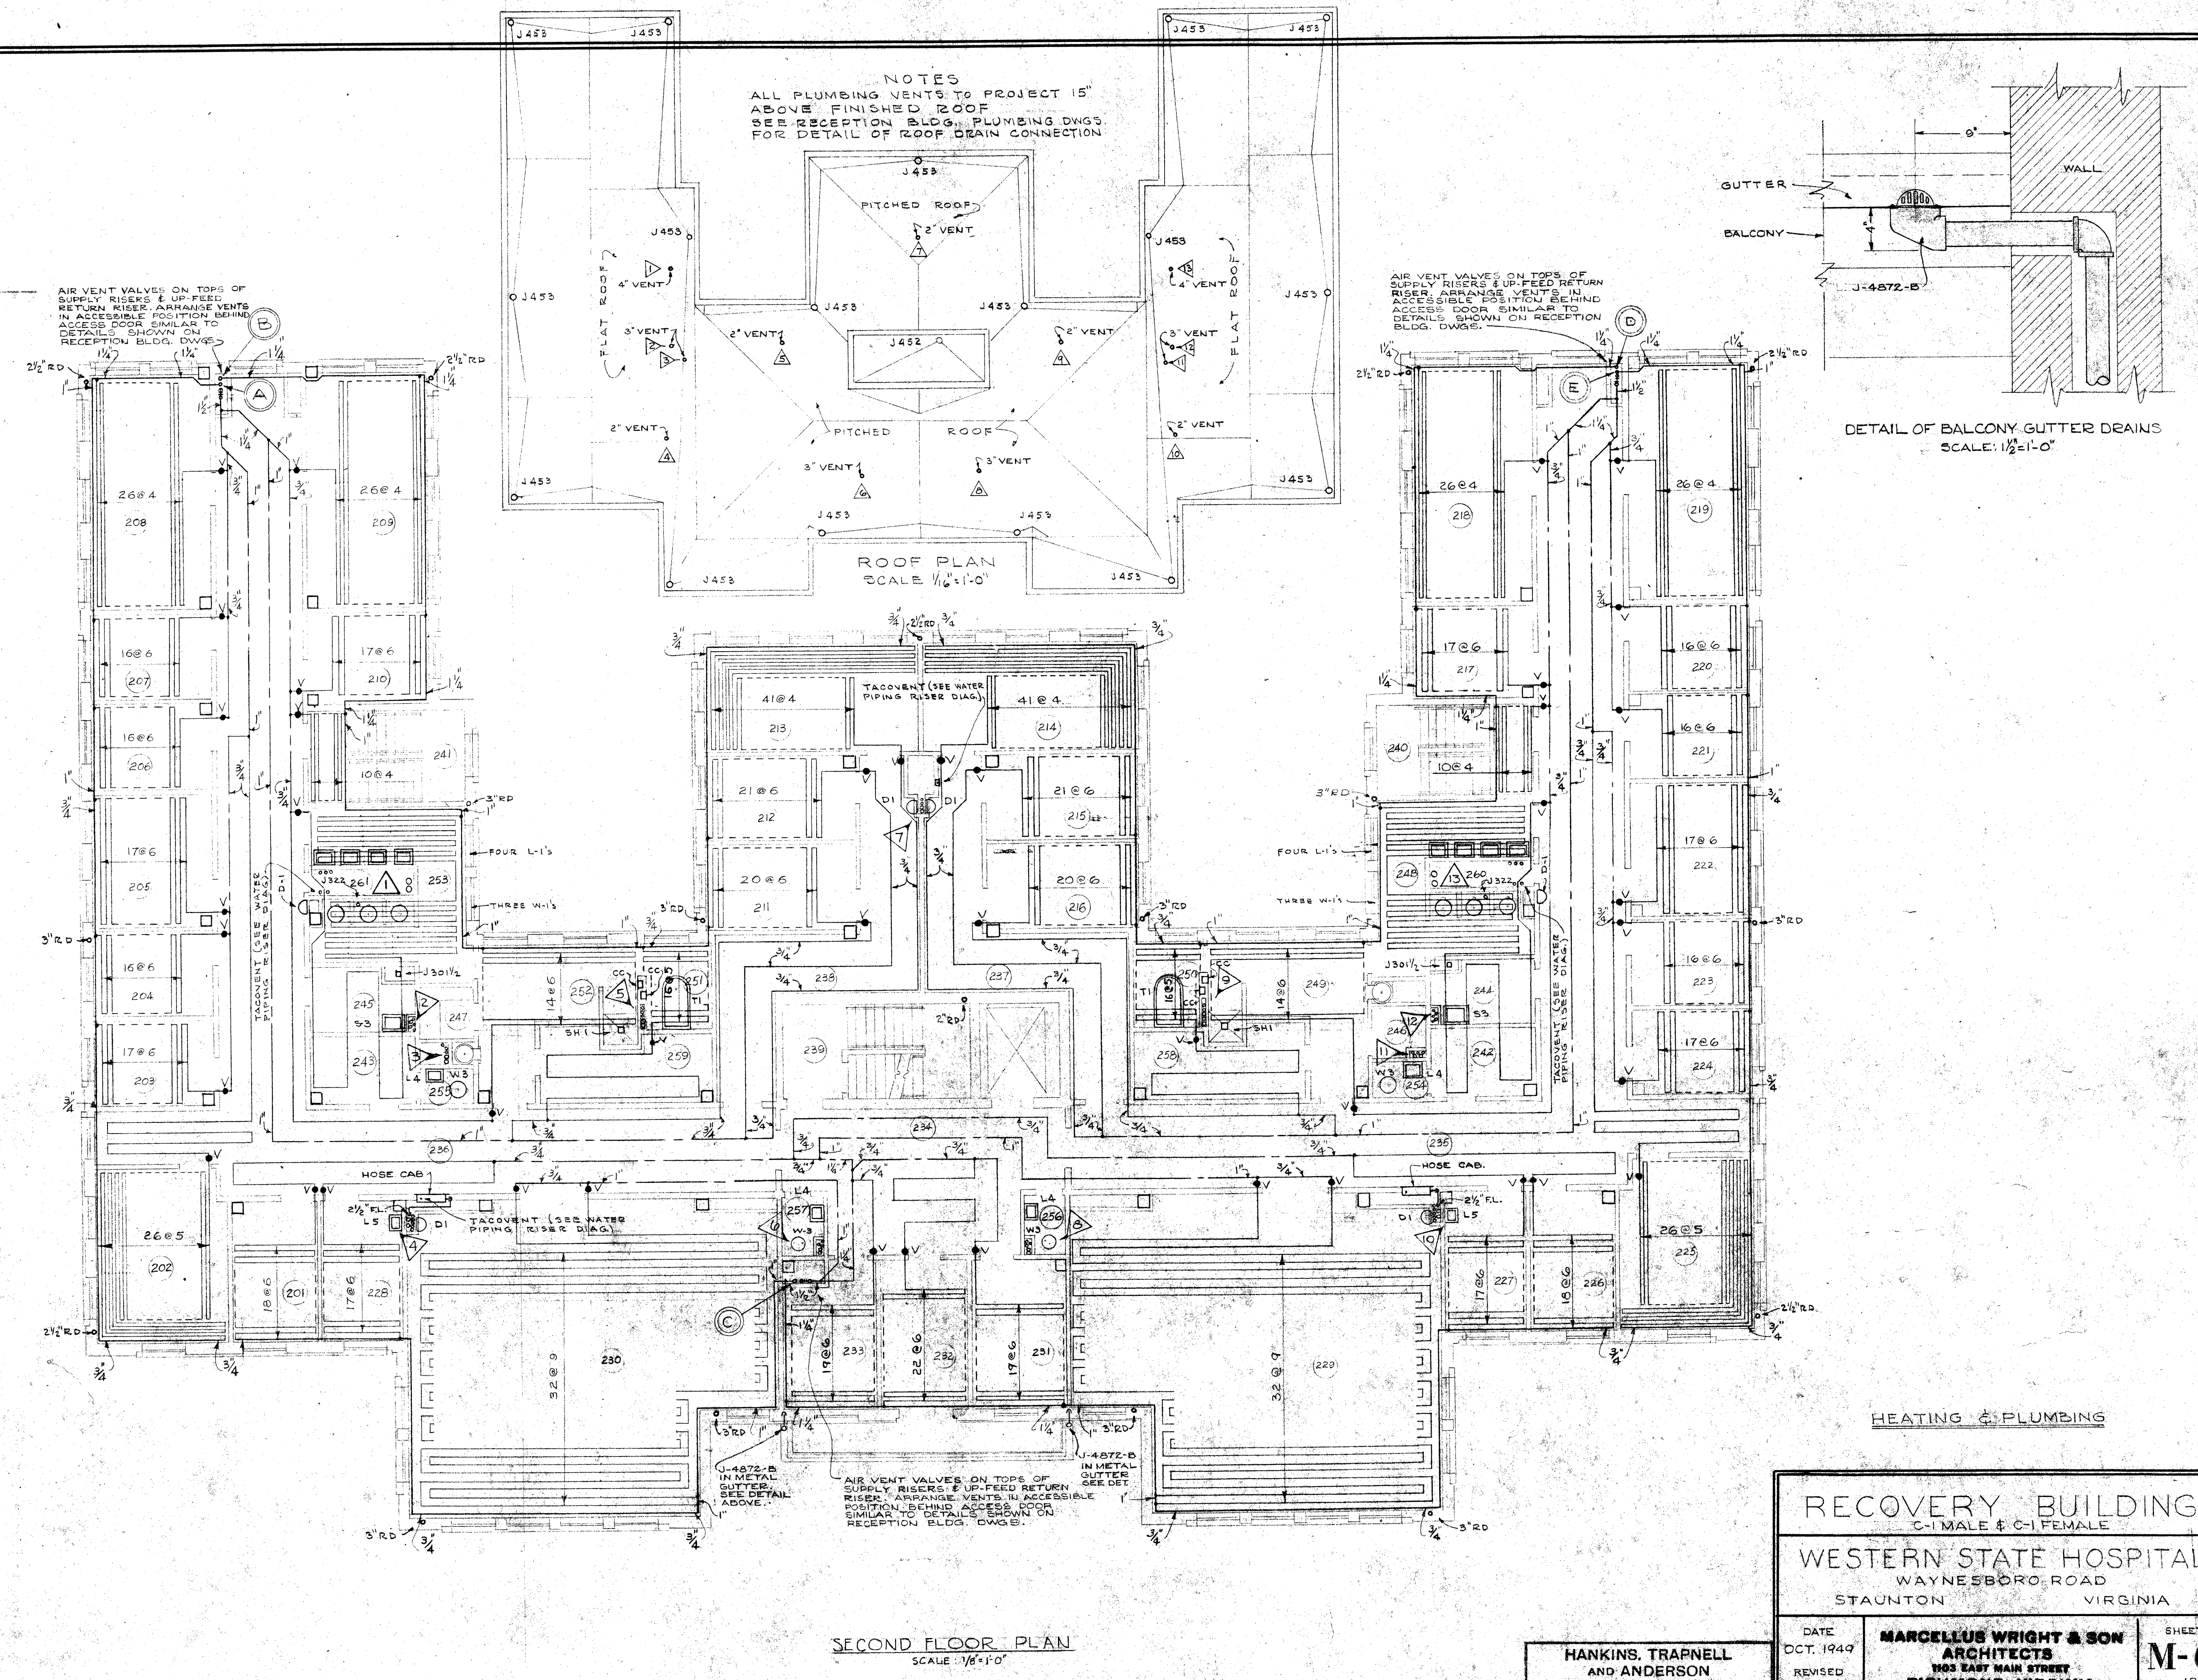

ALL PLUMBING VENTS TO PROJECT 15" ABOVE FINISHED ROOF. SEE RECEPTION BLDG. PLUMBING DWGS. FOR DETAIL OF ROOF DRAIN CONNECTION.

ROOF PLAN
SCALE 1/16"=1'-0"

DETAIL OF BALCONY GUTTER DRAINS
SCALE: 1 1/2"=1'-0"

SECOND FLOOR PLAN
SCALE: 1/8"=1'-0"

HEATING & PLUMBING

RECOVERY BUILDINGS
C-1 MALE & C-1 FEMALE

WESTERN STATE HOSPITAL
WAYNESBORO ROAD
STAUNTON VIRGINIA

DATE
DCT. 1949
REVISED
AUG. 1952
(AS BUILT)

MARCELLUS WRIGHT & SON
ARCHITECTS
103 EAST MAIN STREET
RICHMOND, VIRGINIA

HANKINS, TRAPNELL
AND ANDERSON
CONSULTING ENGINEERS
RICHMOND, VIRGINIA

SHEET
M-6
OF 12