


WESTERN STATE HOSPITAL

VIRGINIA

SUPERINTENDENT

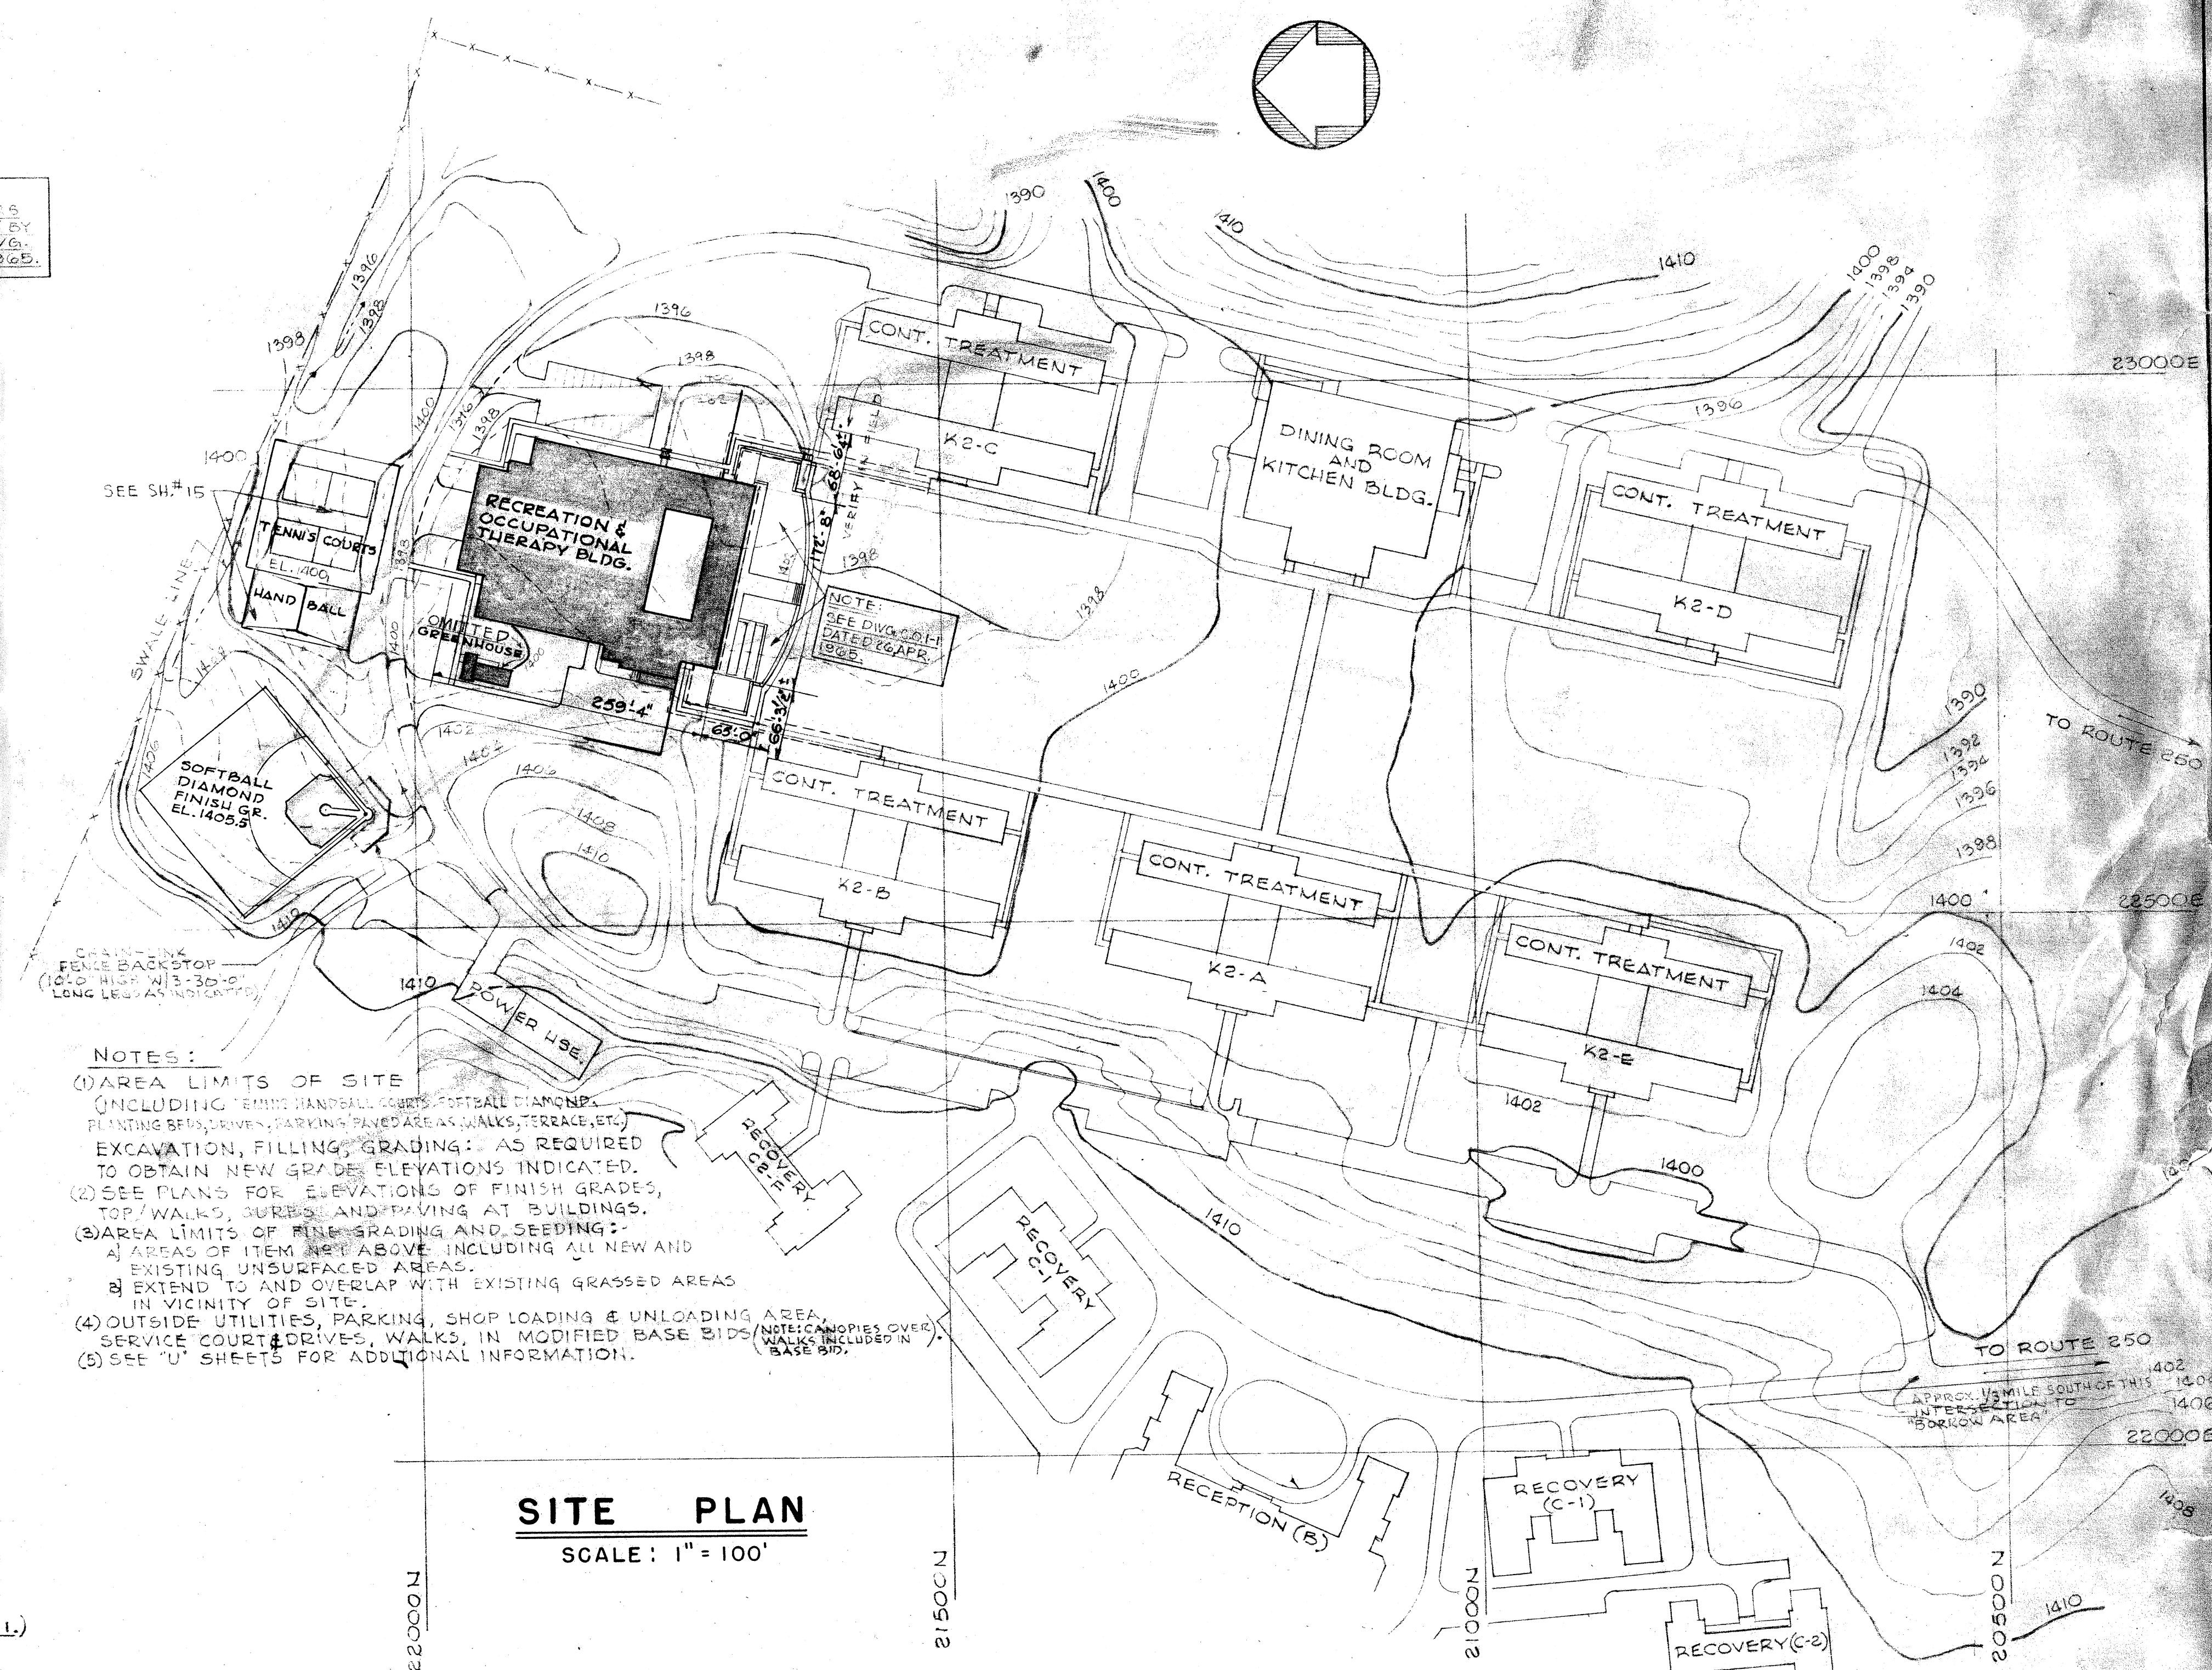



SITE PLAN
SCALE: 1" = 100'

MARCELLUS WRIGHT & SON
ARCHITECTS - RICHMOND , VIRGINIA

HENRY W. ROBERTS - STRUCTURAL ENGINEER
RICHMOND, VIRGINIA

SEPTEMBER 1964
"AS BUILT" - DECEMBER, 1966

SOE File No.
706-121.1

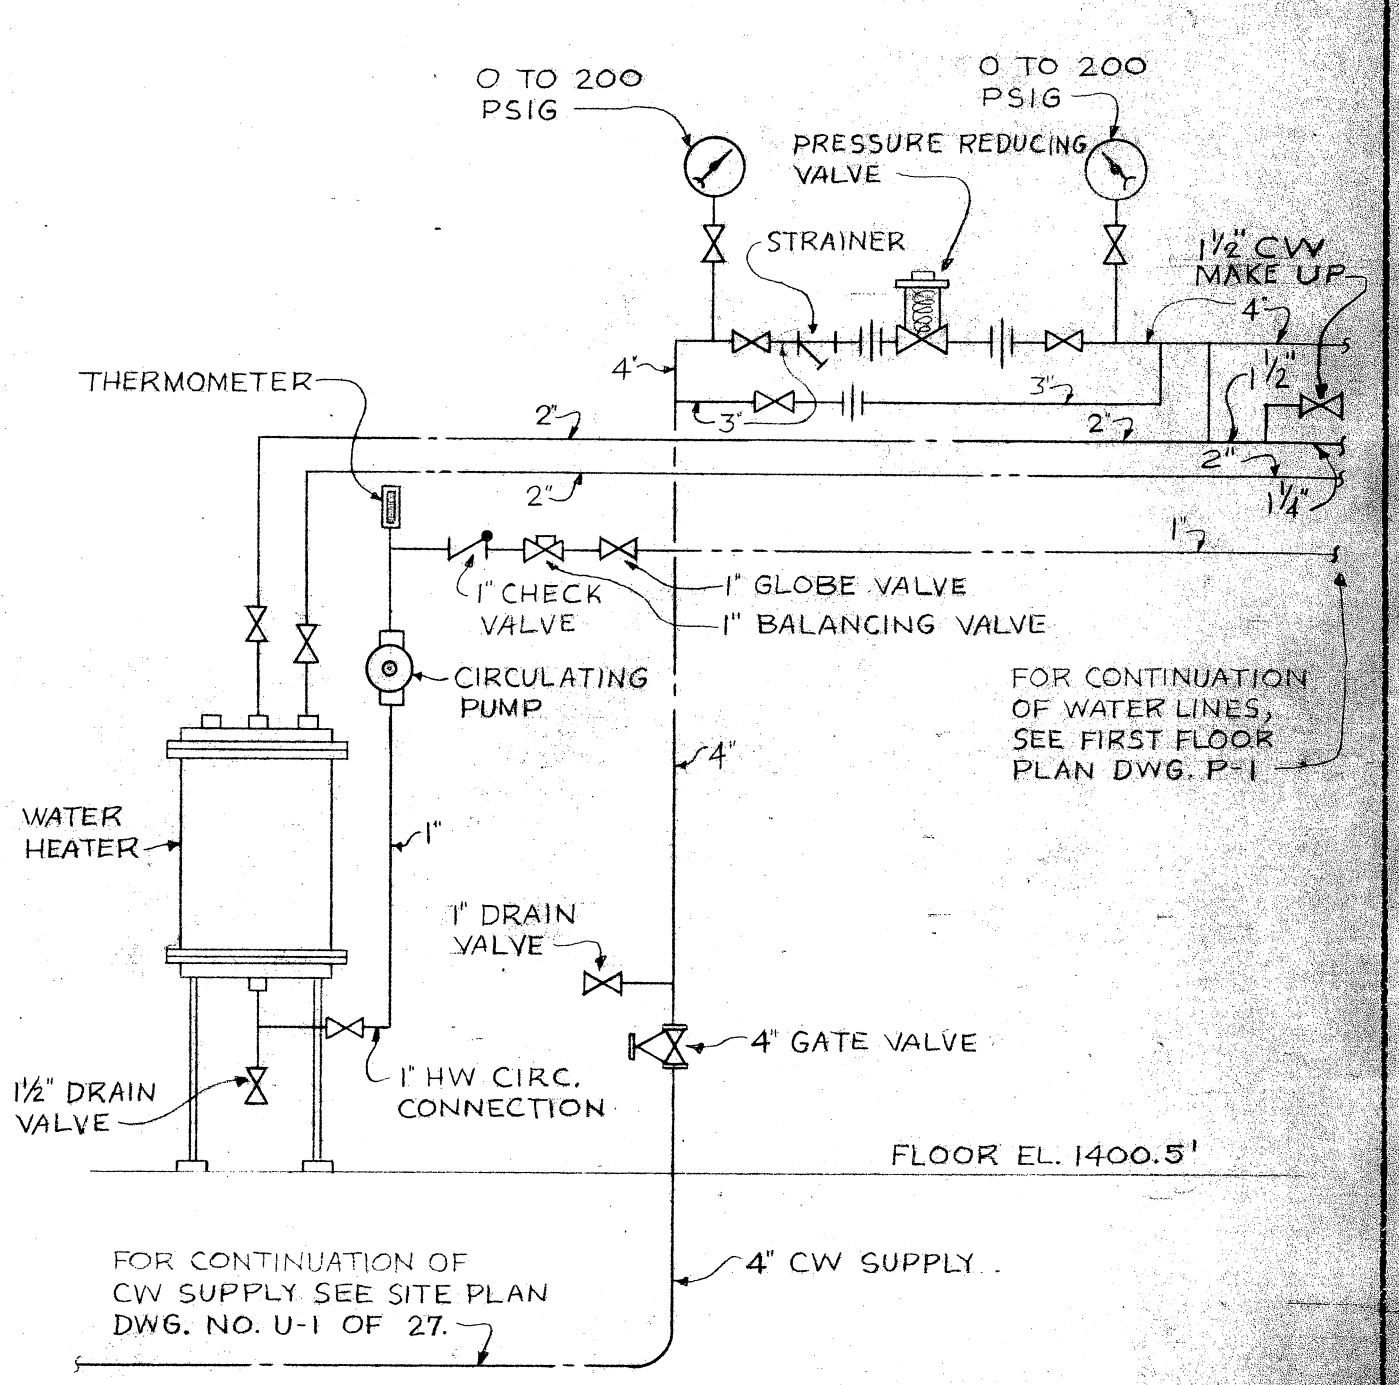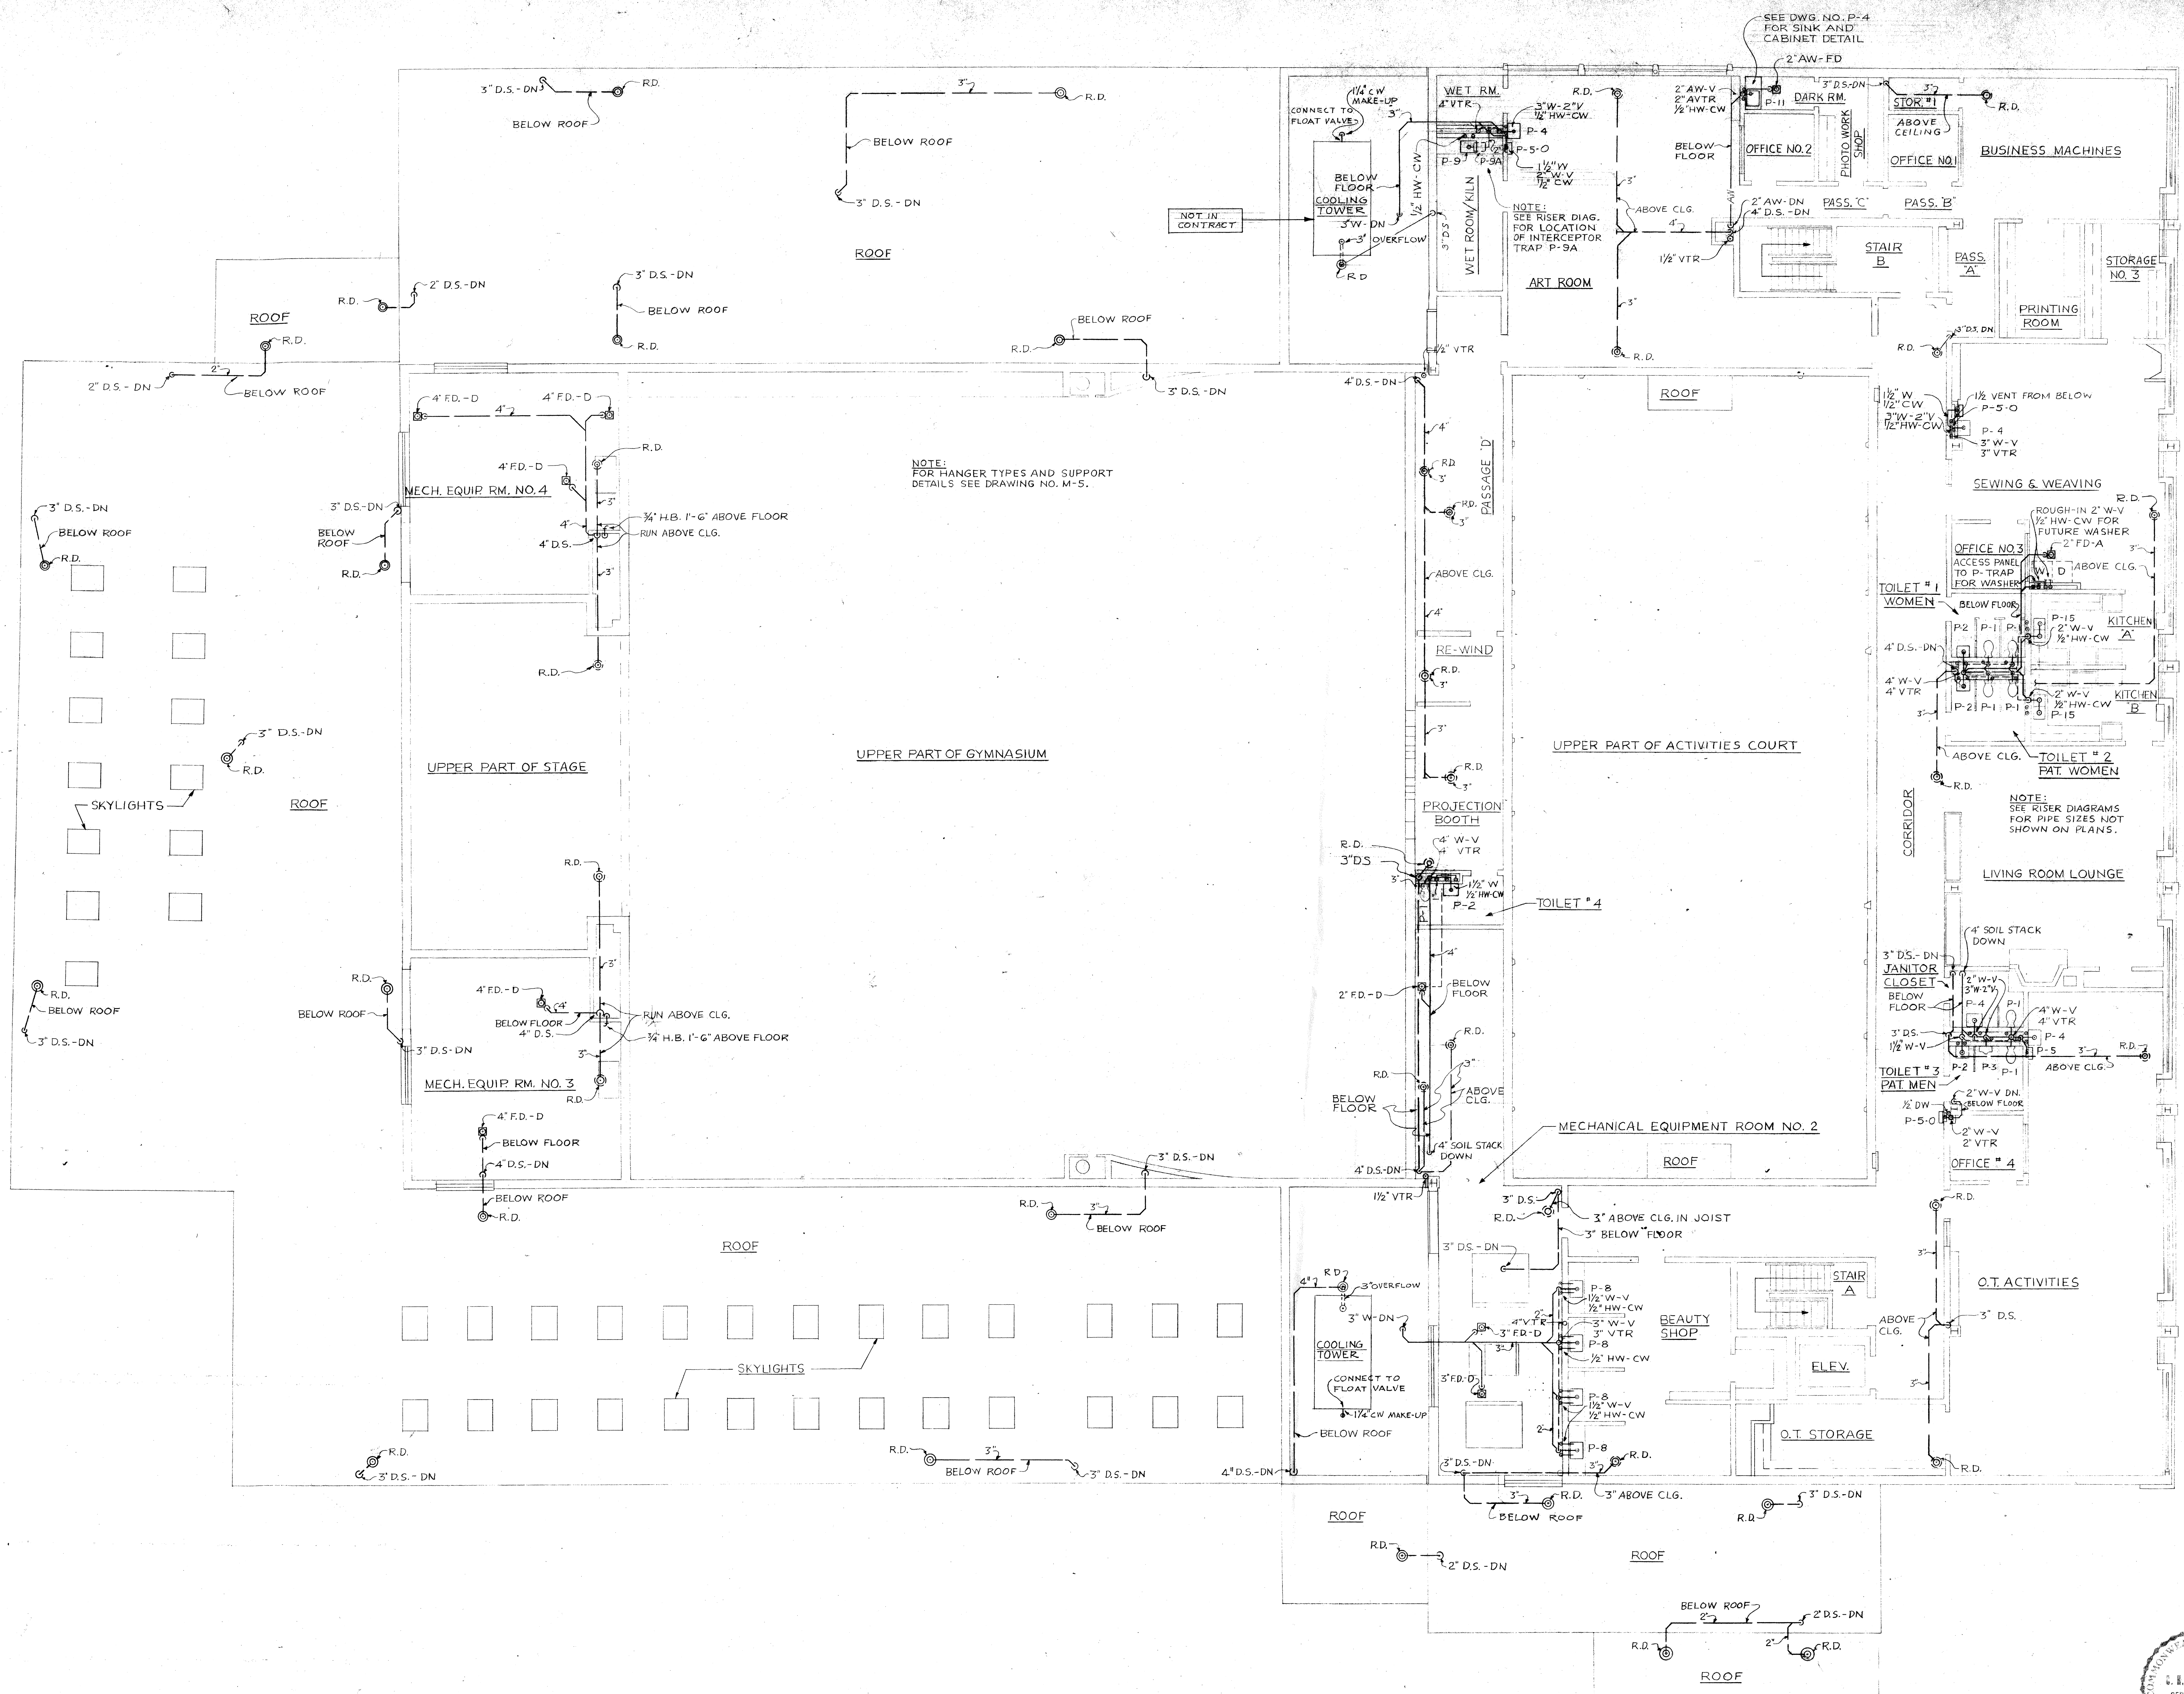

SECOND FLOOR PLAN
SCALE 1/8" = 1'-0"


Risers for Stripling

AS BUILT PLAN
THIS PLAN SHOWS FINAL
CONSTRUCTION AS OF
DEC 1966




WILEY & WILSON
CONSULTING ENGINEERS
LEXINGTON, VA. RICHMOND, VA.


PLUMBING SECOND FLOOR PLAN	
RECREATION & OCCUPATIONAL THERAPY BUILDING	
WESTERN STATE HOSPITAL WAYNESBORO ROAD STAUNTON, VIRGINIA	
DATE SEPT. 1964	SHEET P-2
MARCELLUS WRIGHT & SON ARCHITECTS 100 EAST MAIN STREET RICHMOND, VIRGINIA	

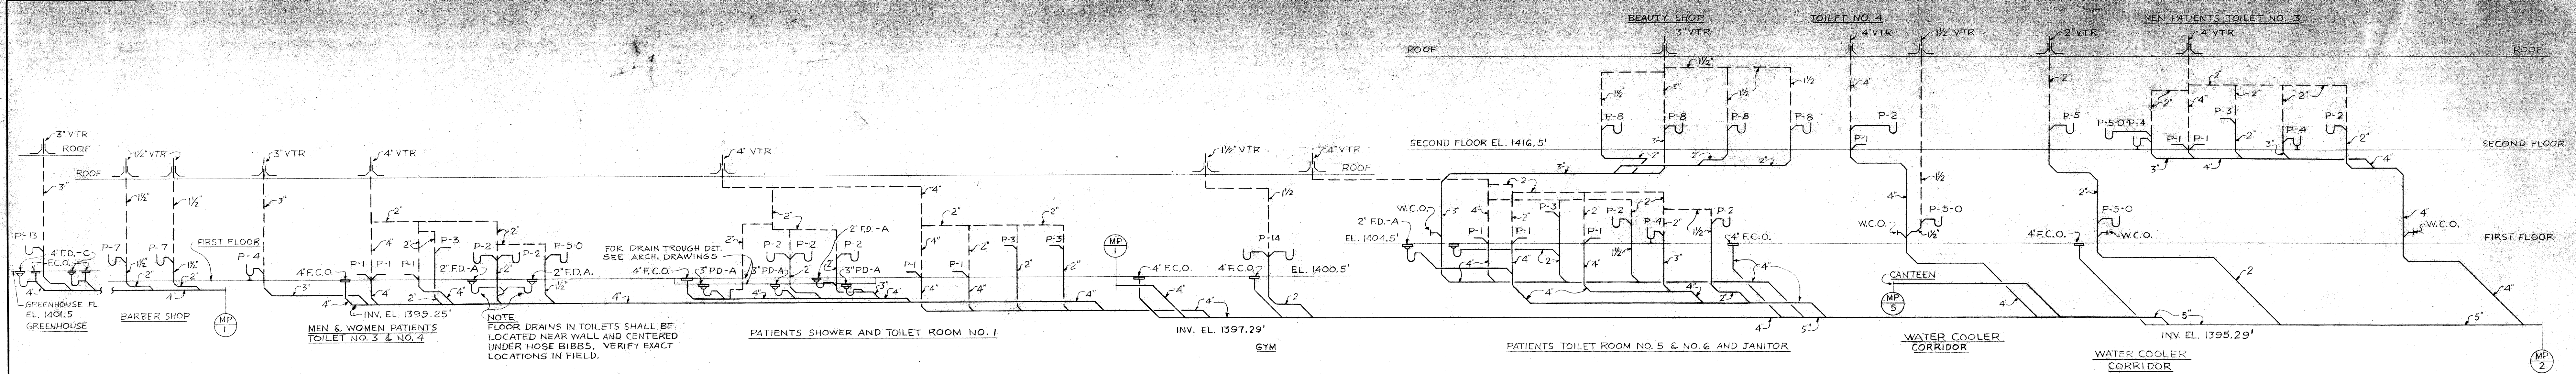


SOIL, WASTE AND VENT RISER DIAGRAM
NOT TO SCALE

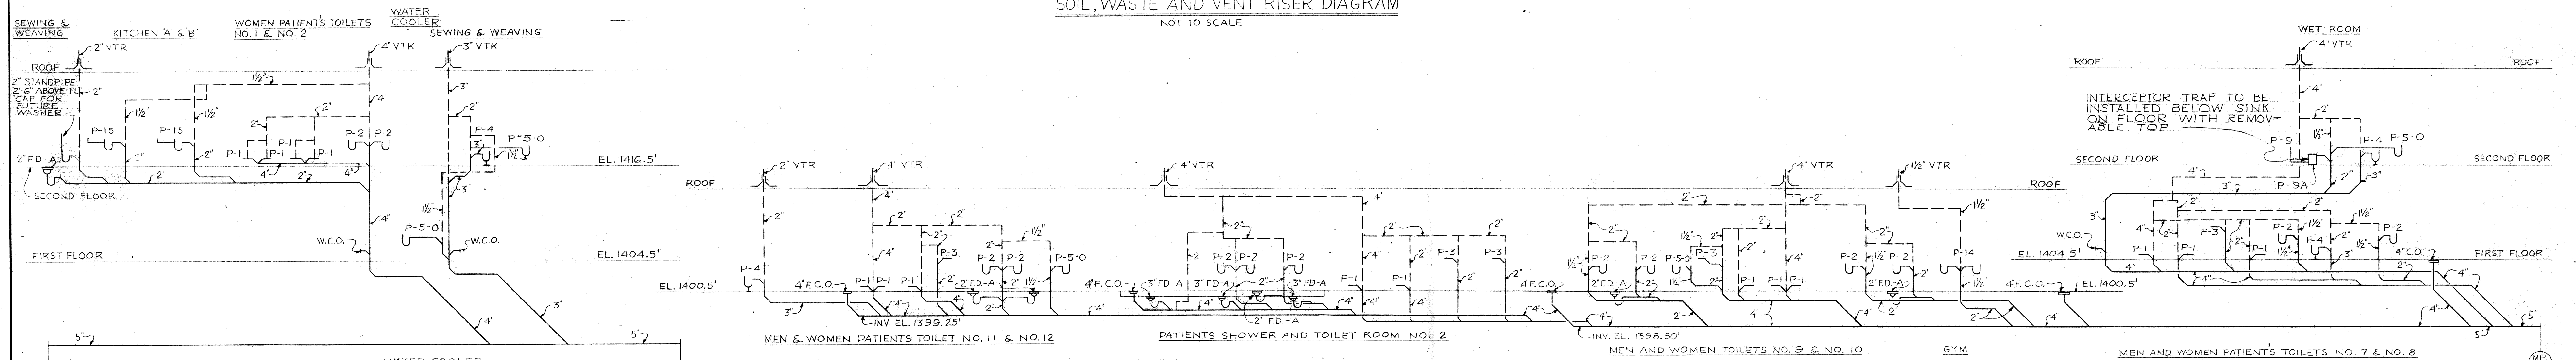

SOIL, WASTE AND VENT RISER DIAGRAM
NOT TO SCALE

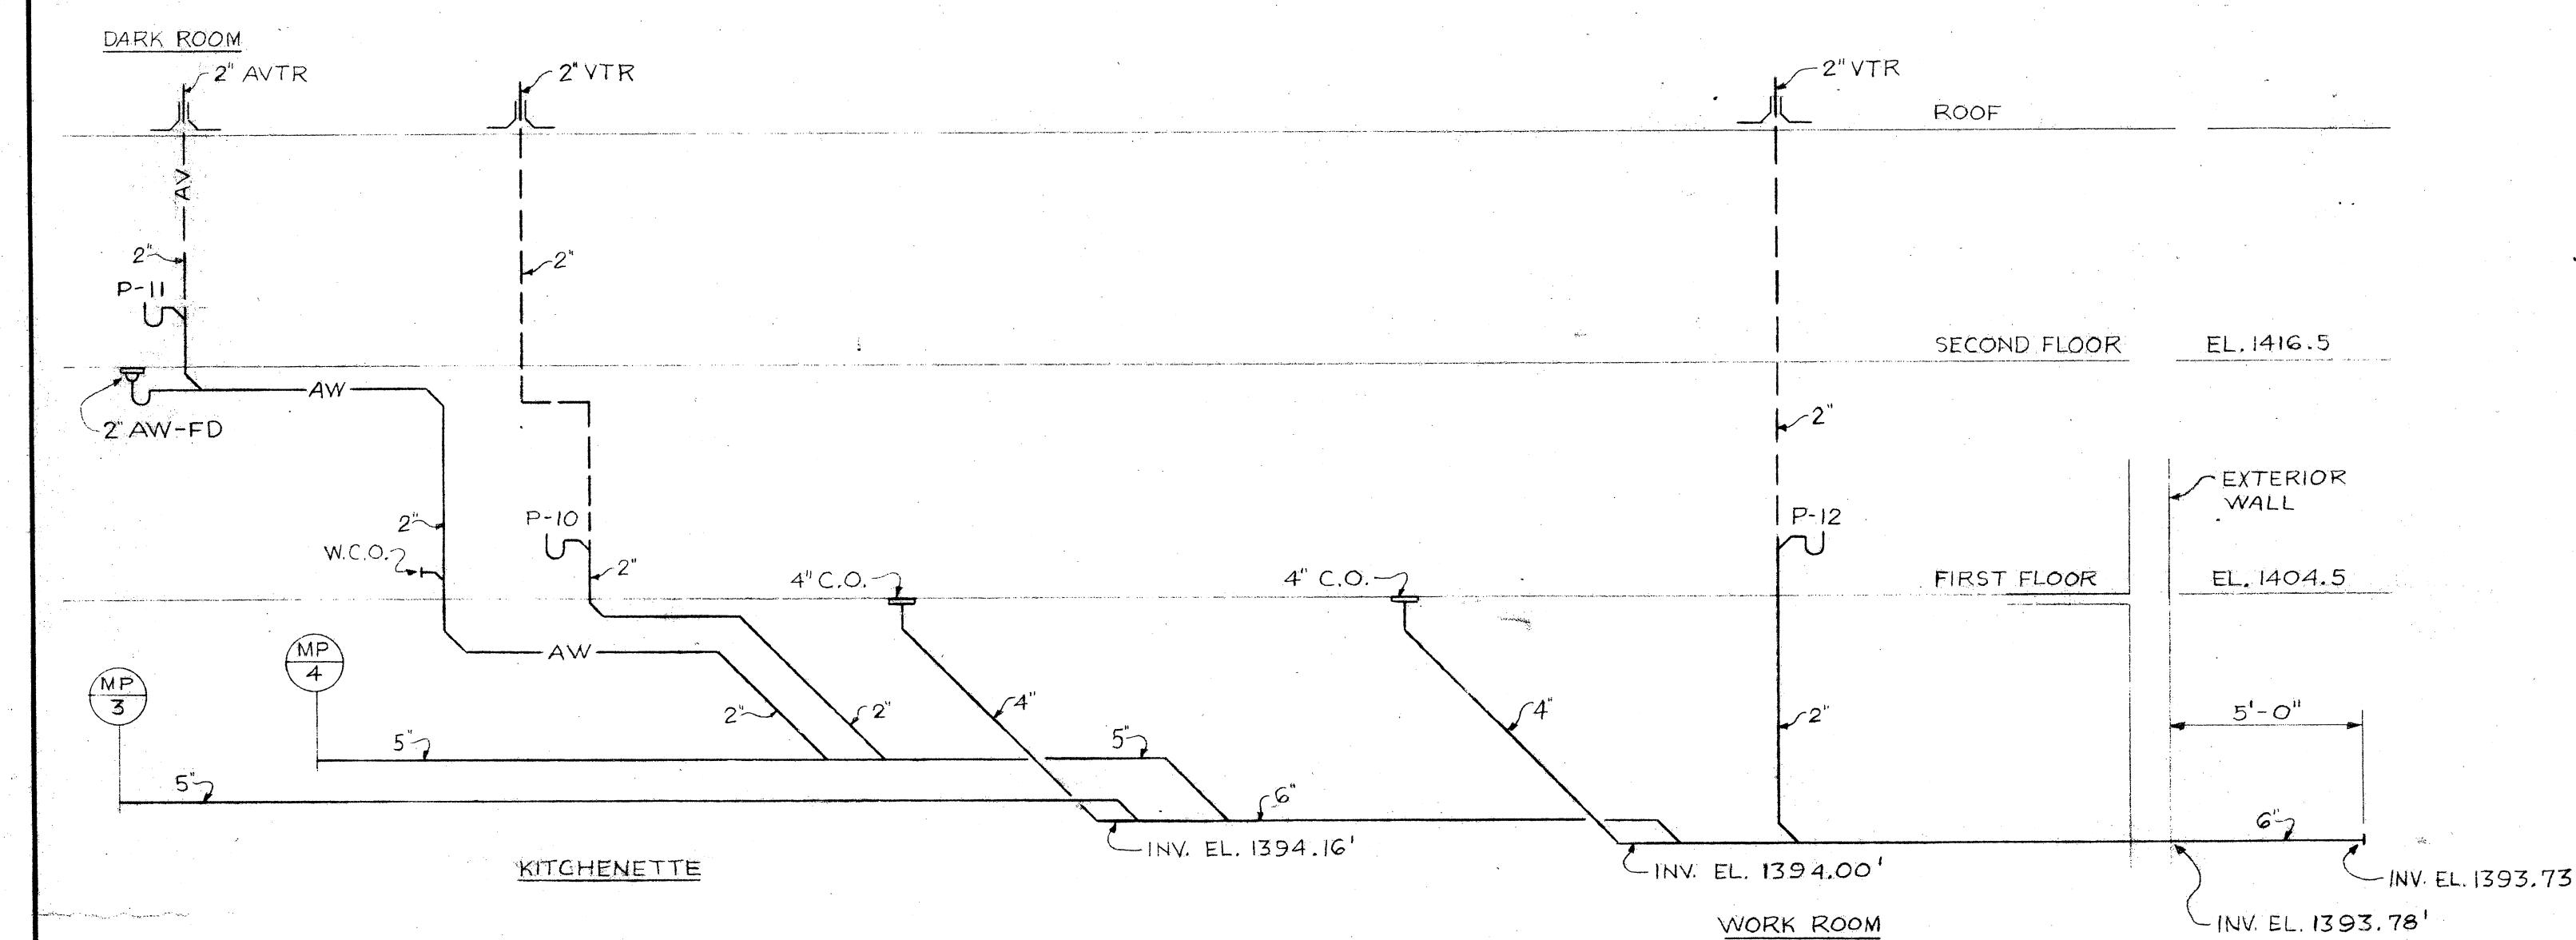


SOIL, WASTE AND VENT RISER DIAGRAM
NOT TO SCALE

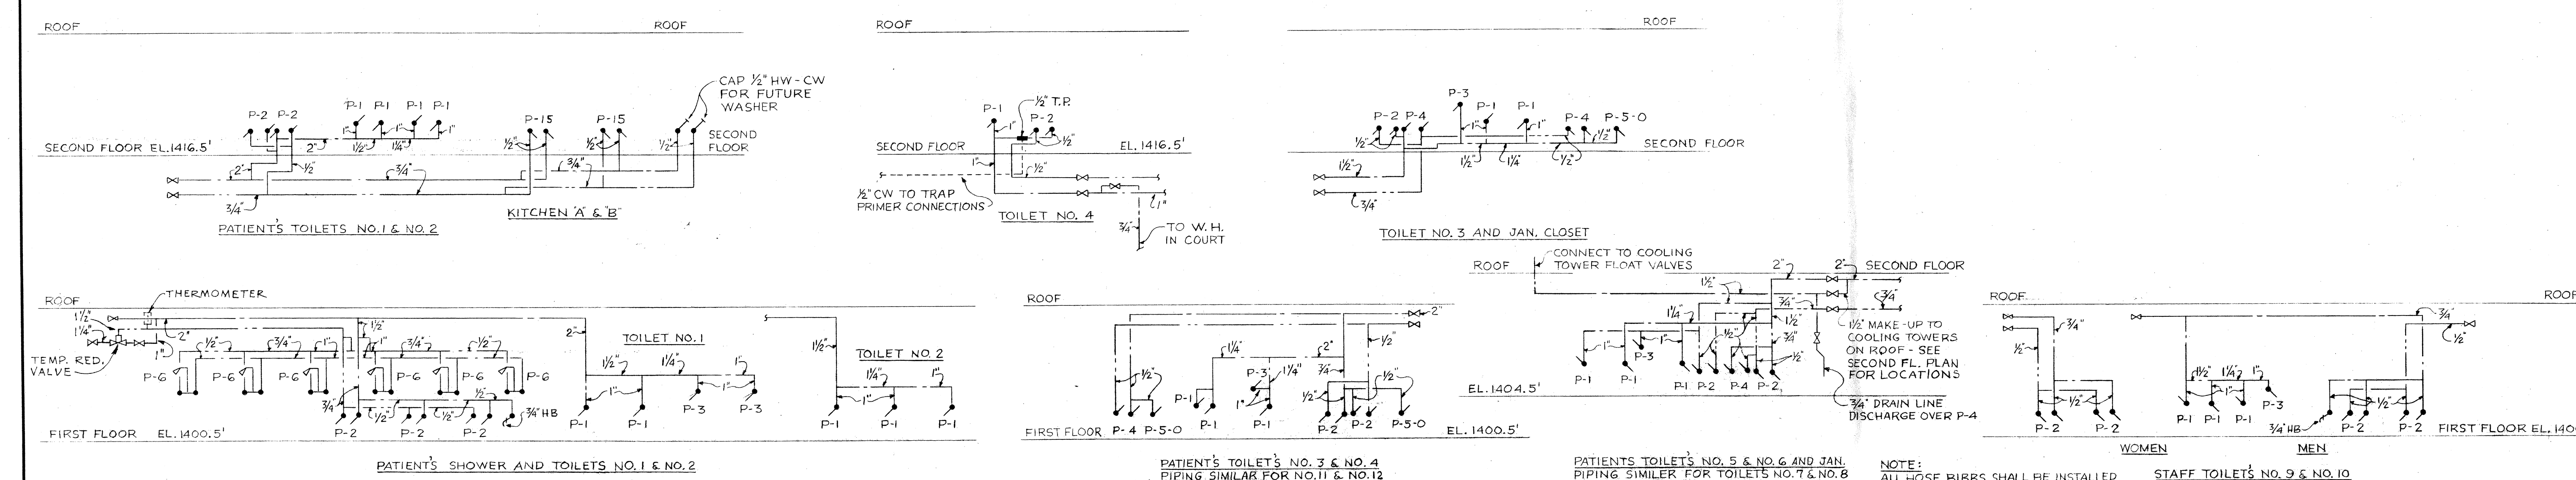

HOT AND COLD WATER RISER DIAGRAM
NOT TO SCALE


NOTE:
ALL ROSE BIBBS SHALL BE INSTALLED
1'-6" ABOVE FINISHED FLOOR AND
CENTERED OVER FLOOR DRAINS
WHICH SHALL BE NEAR WALL.
VERIFY EXACT LOCATION IN FIELD.
ALL TOILETS DO NOT HAVE ROSE BIBBS.

AS-BUILT PLAN
THIS PLAN SHOWS FINAL
CONSTRUCTION AS OF
1964

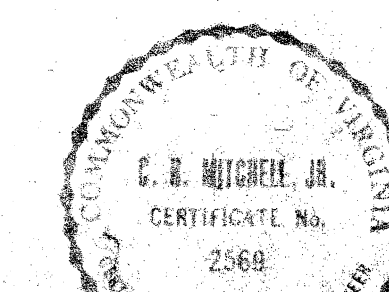

WILEY & WILSON
CONSULTING ENGINEERS
LYNCHBURG, VA. RICHMOND, VA.

PLUMBING
RISER DIAGRAMS
RECREATION & OCCUPATIONAL THERAPY
BUILDING
WESTERN STATE HOSPITAL
WAYNESBORO ROAD
STAUNTON VIRGINIA
DATE: SEPT. 1964
REVISED
MARCELLUS WRIGHT & SON
ARCHITECTS
100 EAST MAIN STREET
RICHMOND VIRGINIA
SHEET
P-3
OF 4

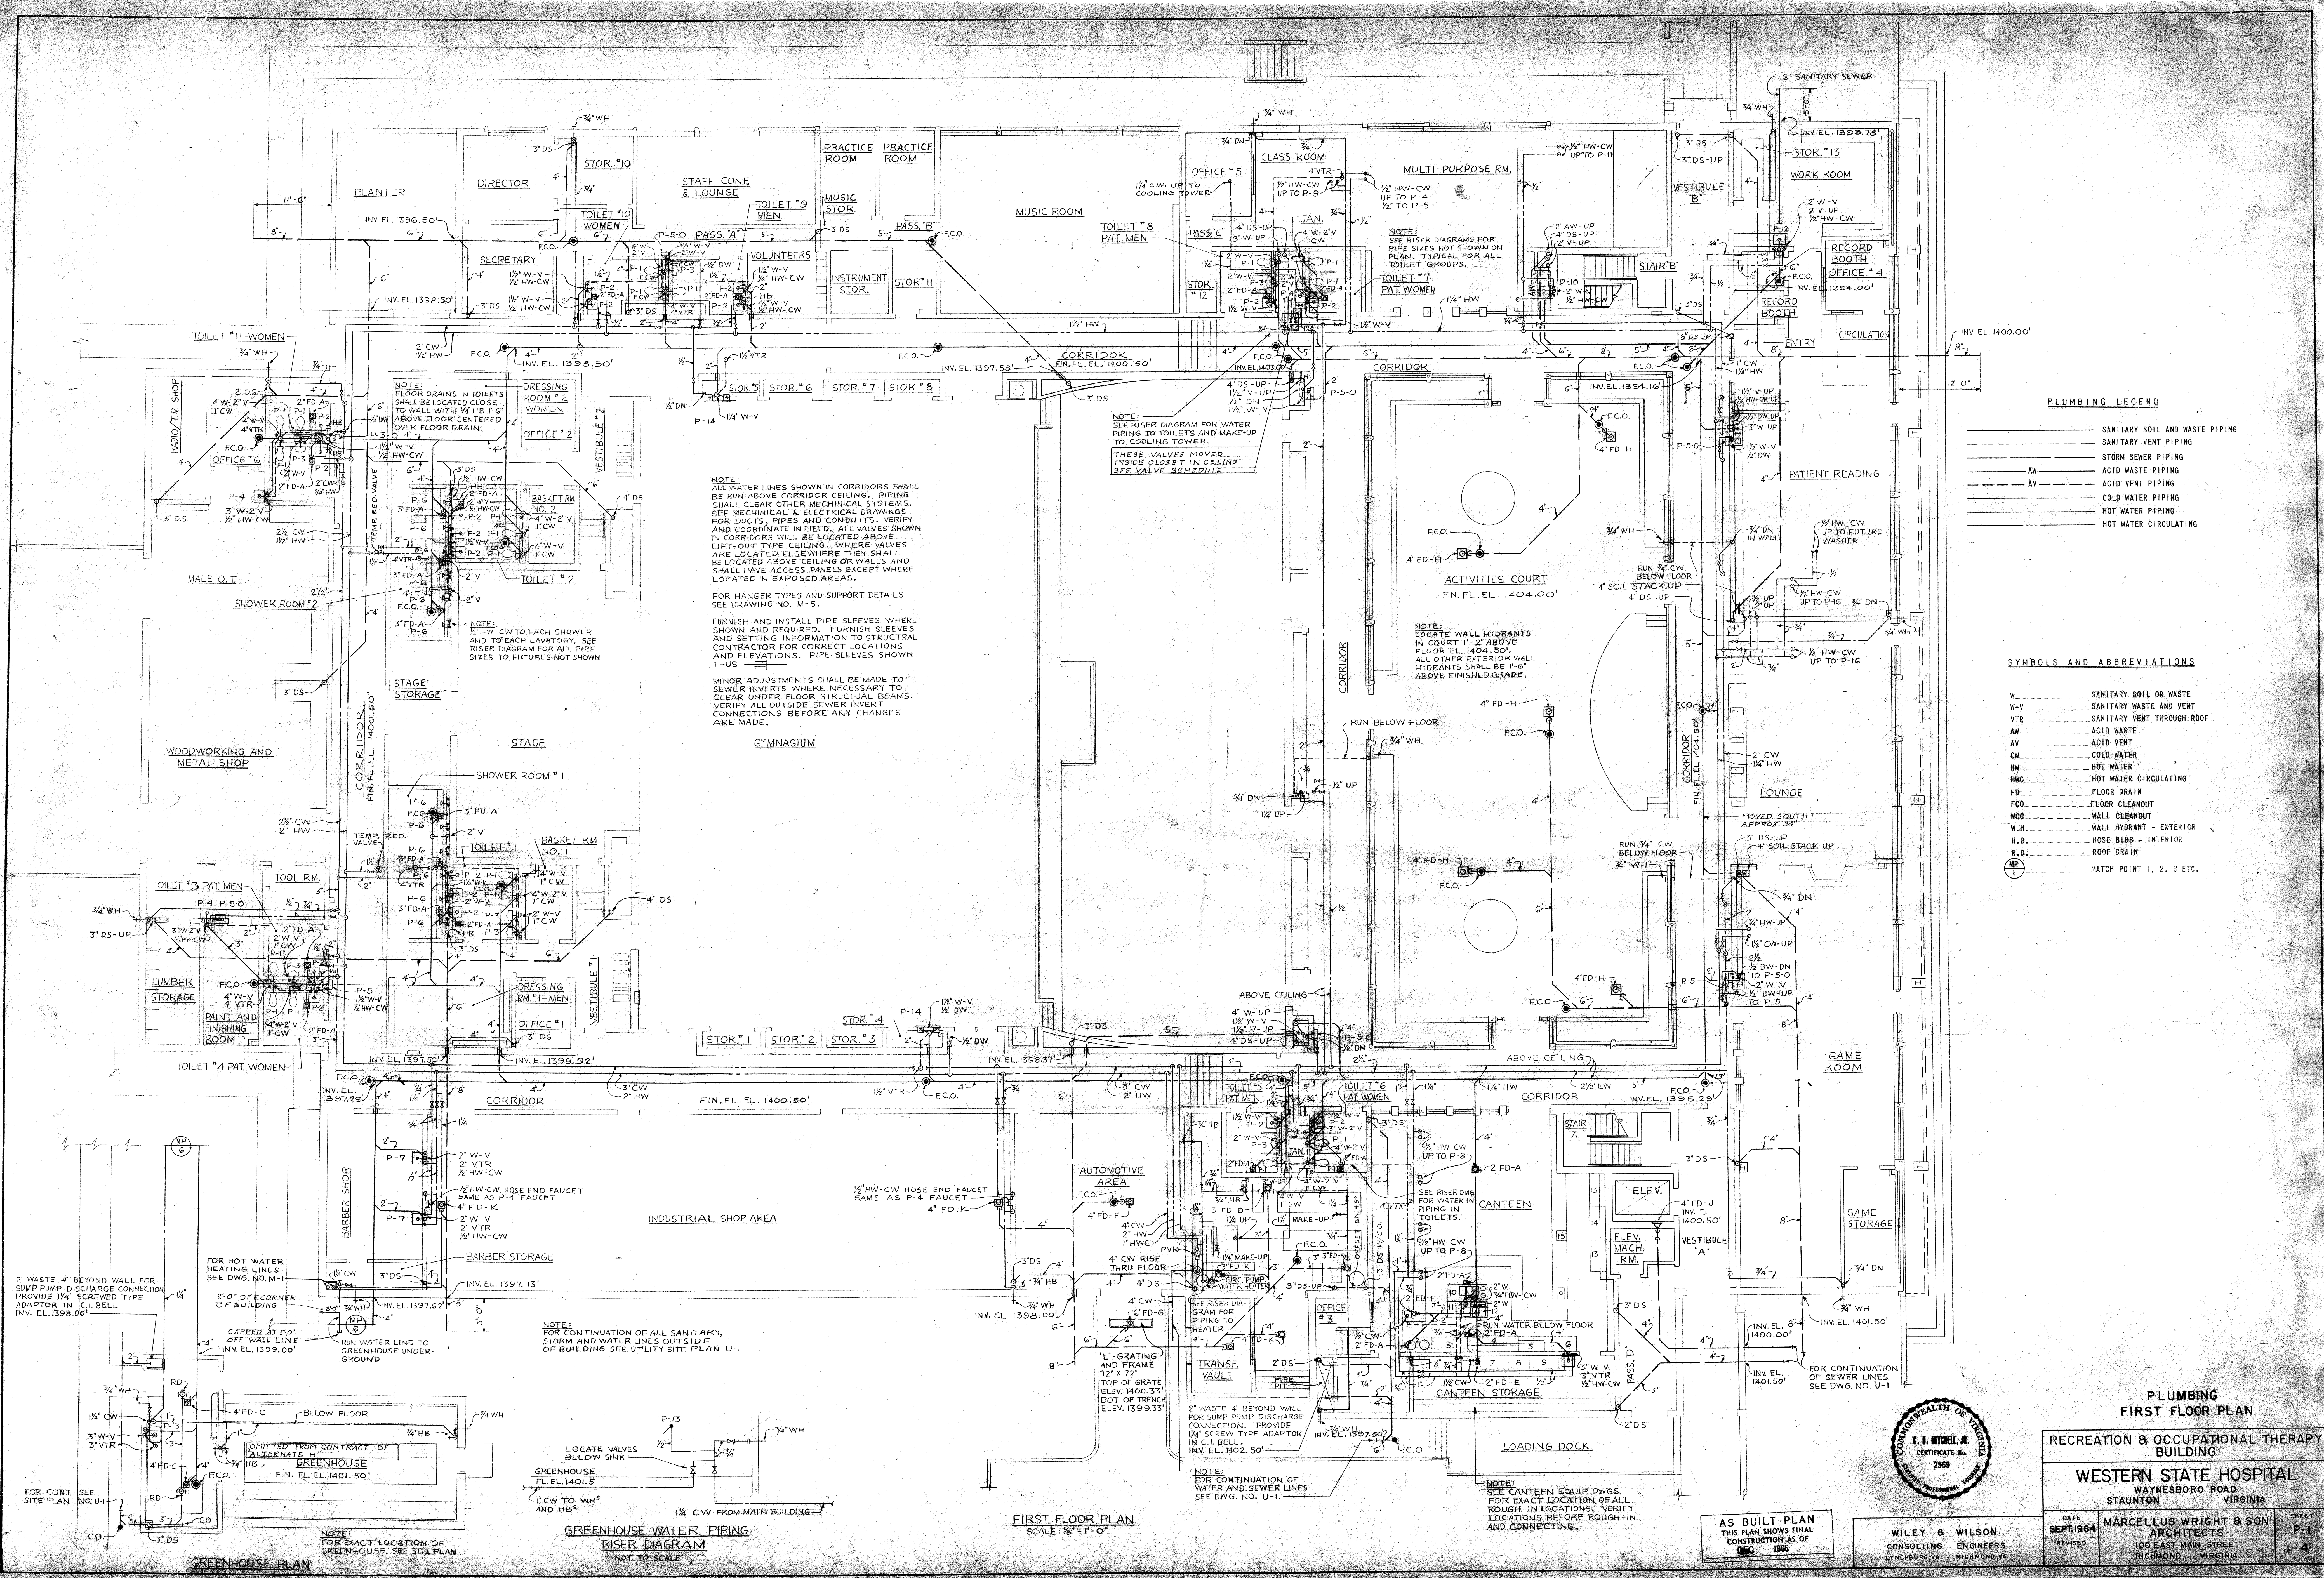

PLUMBING LEGEND

---	SANITARY SOIL AND WASTE PIPING
---	SANITARY VENT PIPING
---	STORM SEWER PIPING
---	ACID WASTE PIPING
---	ACID VENT PIPING
---	COLD WATER PIPING
---	HOT WATER PIPING
---	HOT WATER CIRCULATING

SYMBOLS AND ABBREVIATIONS

W	SANITARY SOIL OR WASTE
W-V	SANITARY WASTE AND VENT
VTR	SANITARY VENT THROUGH ROOF
AW	ACID WASTE
AV	ACID VENT
CW	COLD WATER
HW	HOT WATER
HWC	HOT WATER CIRCULATING
FD	FLOOR DRAIN
FCD	FLOOR CLEANOUT
WOO	WALL CLEANOUT
W.H.	WALL HYDRANT - EXTERIOR
H.B.	HOSE BIBB - INTERIOR
R.D.	ROOF DRAIN
MP	MATCH POINT 1, 2, 3 ETC.

PLUMBING FIRST FLOOR PLAN

RECREATION & OCCUPATIONAL THERAPY BUILDING

WESTERN STATE HOSPITAL
WAYNESBORO ROAD
STAUNTON, VIRGINIA

MARCELLUS WRIGHT & SONS
ARCHITECTS
100 EAST MAIN STREET
RICHMOND, VIRGINIA

DATE: SEPTEMBER 1964
REVISED: _____

AS BUILT PLAN
THIS PLAN SHOWS FINAL
CONSTRUCTION AS OF
1966

WILEY & WILSON
CONSULTING ENGINEERS
LYNCHBURG, VA. - RICHMOND, VA.

DATE: SEPTEMBER 1964
REVISED: _____

DATE: SEPTEMBER 1964
REVISED: _____

SHEET P-1 OF 4