
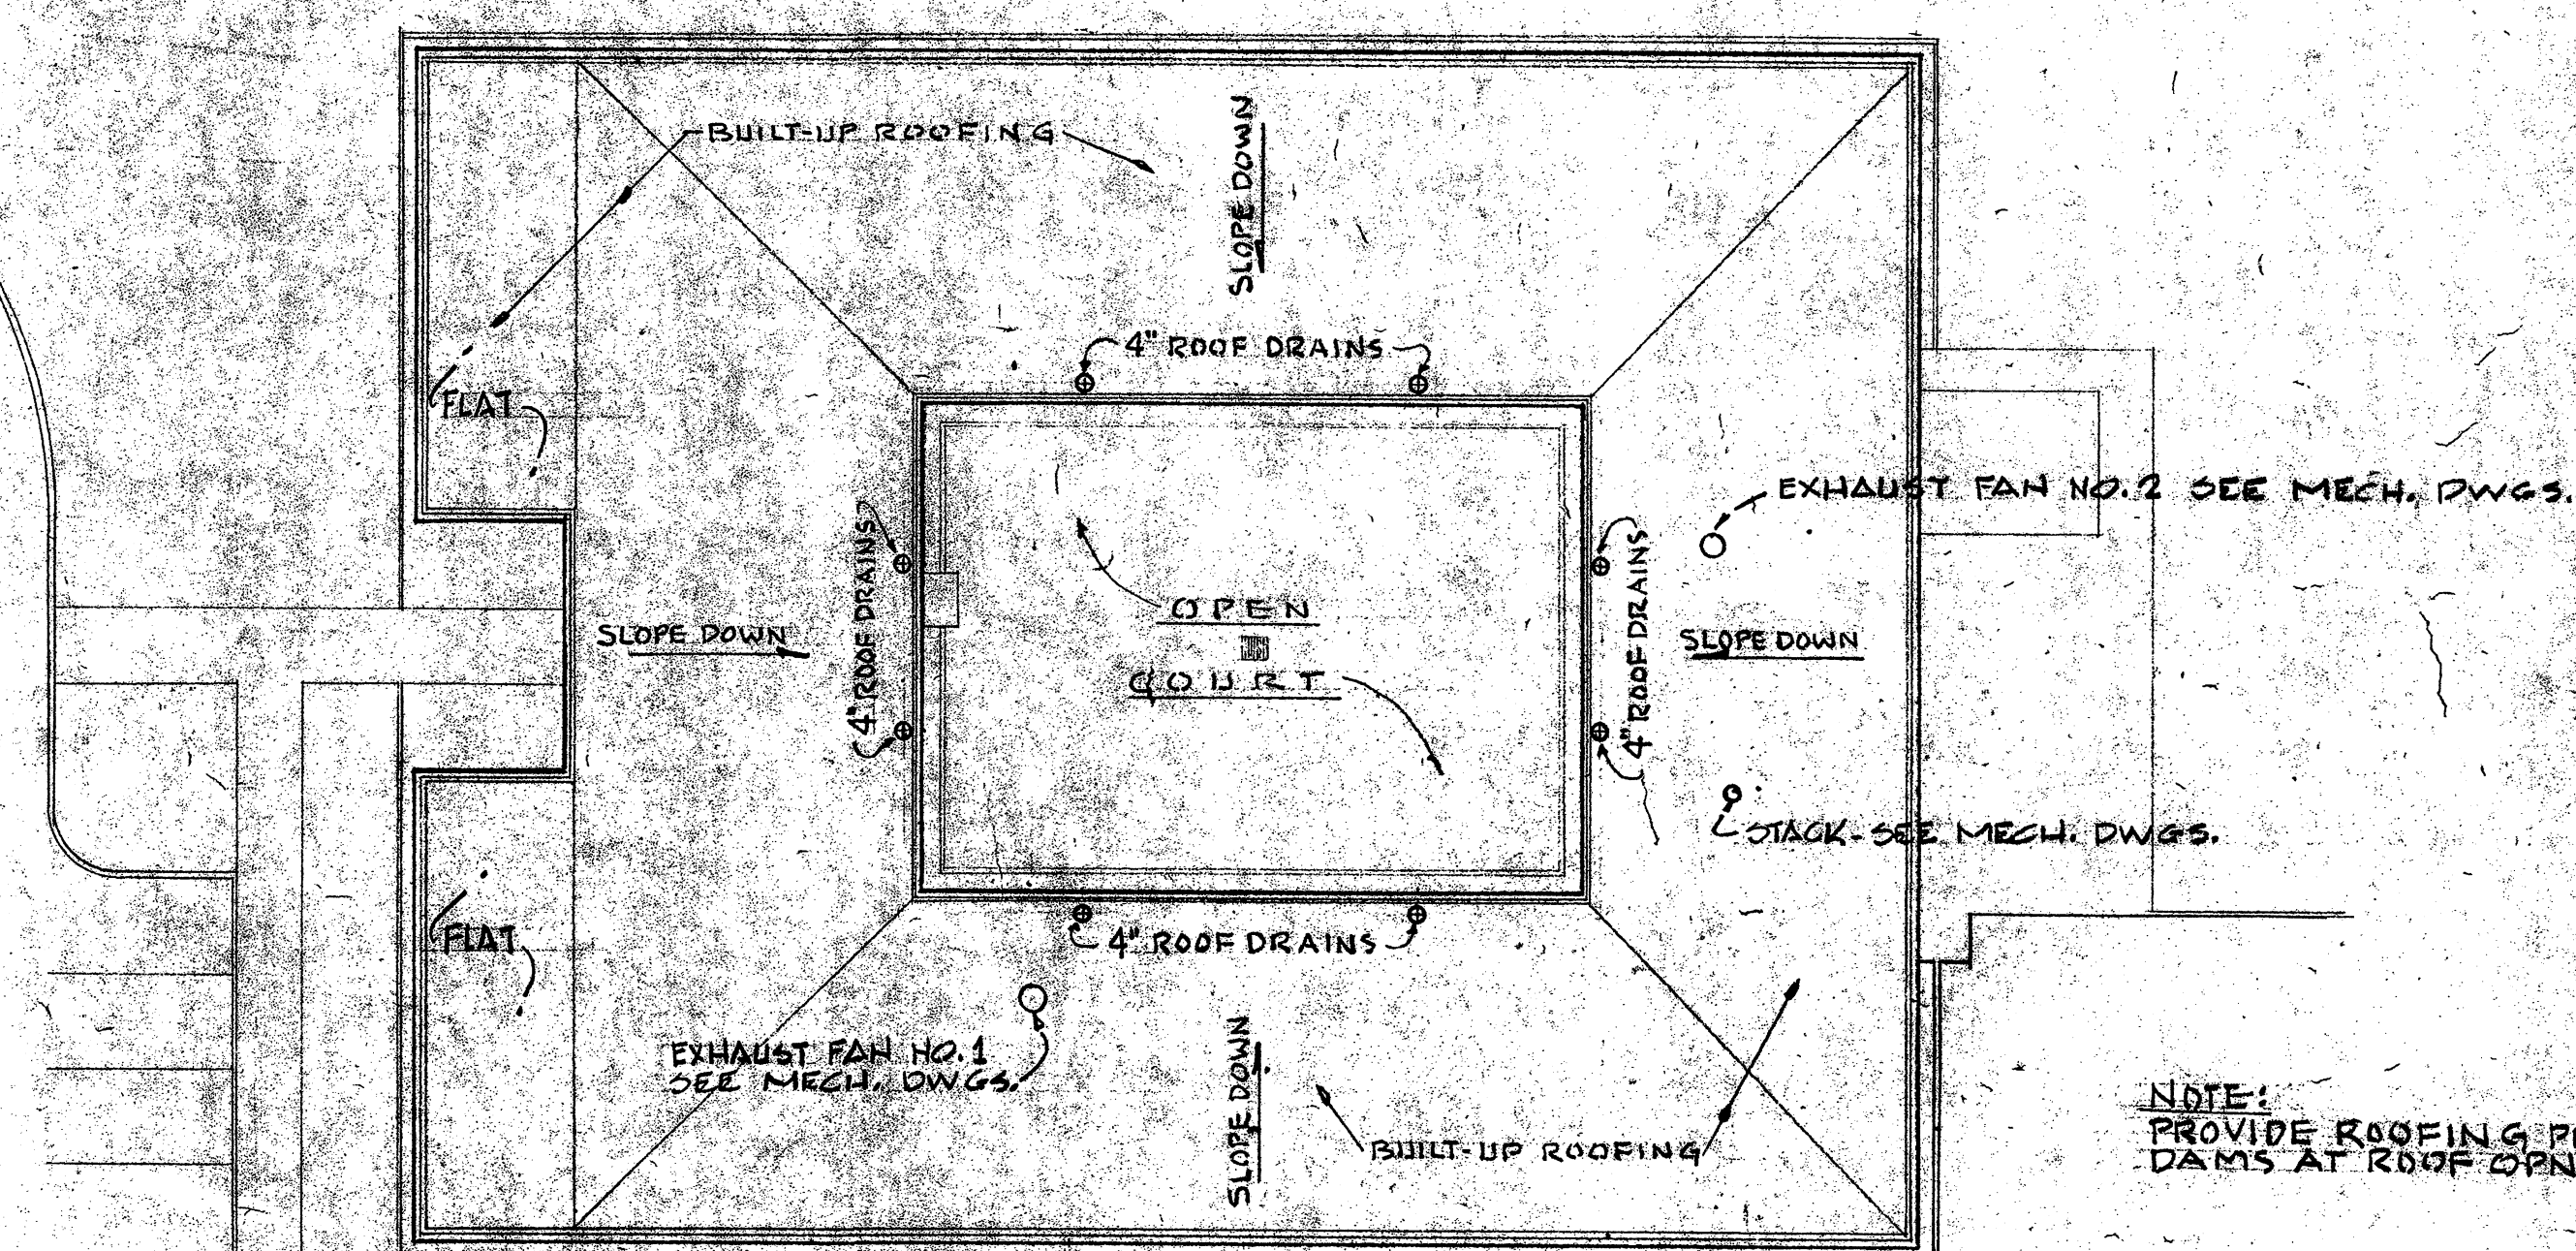


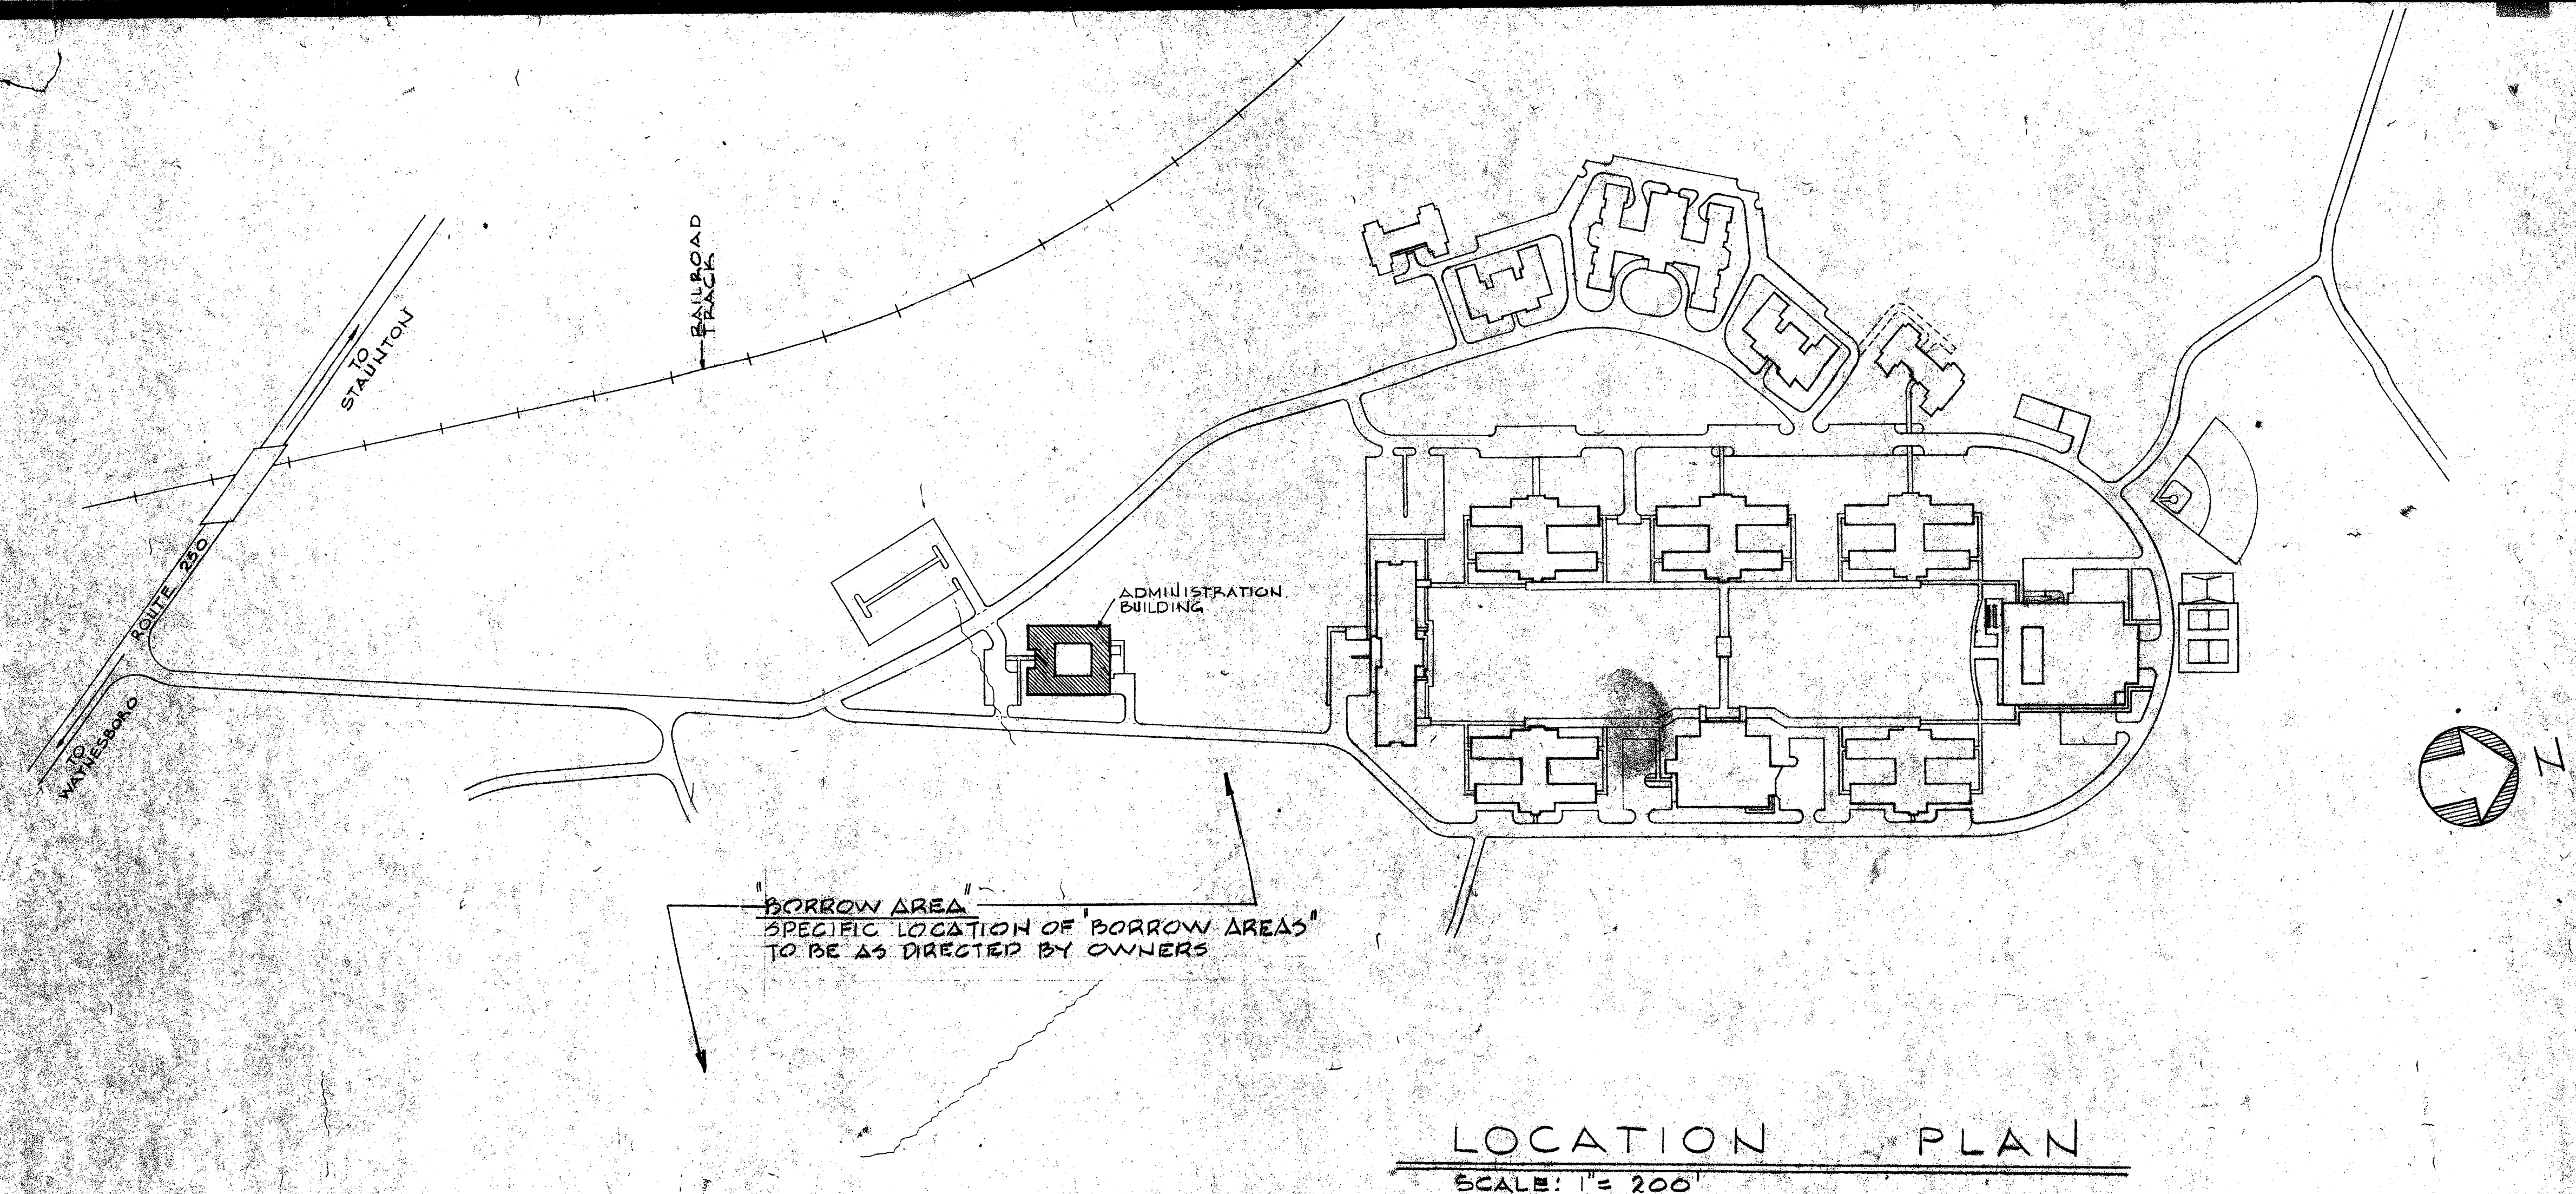


"AS BUILT DWGS" 8.28.73

ADMINISTRATION BUILDING
WESTERN STATE HOSPITAL (NEW SITE)

STAUNTON

VIRGINIA

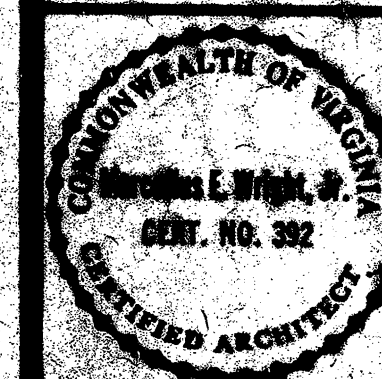

REVISIONS

DATE

BY

NO.

DATE

BY

NO.

DATE

MARCELLUS WRIGHT & PARTNERS
ARCHITECTS

CROZET HOUSE 100 E. MAIN STREET
RICHMOND, VIRGINIA 23219


SHEET NO.

1 OF 10




DATE

JULY, 1970


LOCATION PLAN & ROOF PLAN

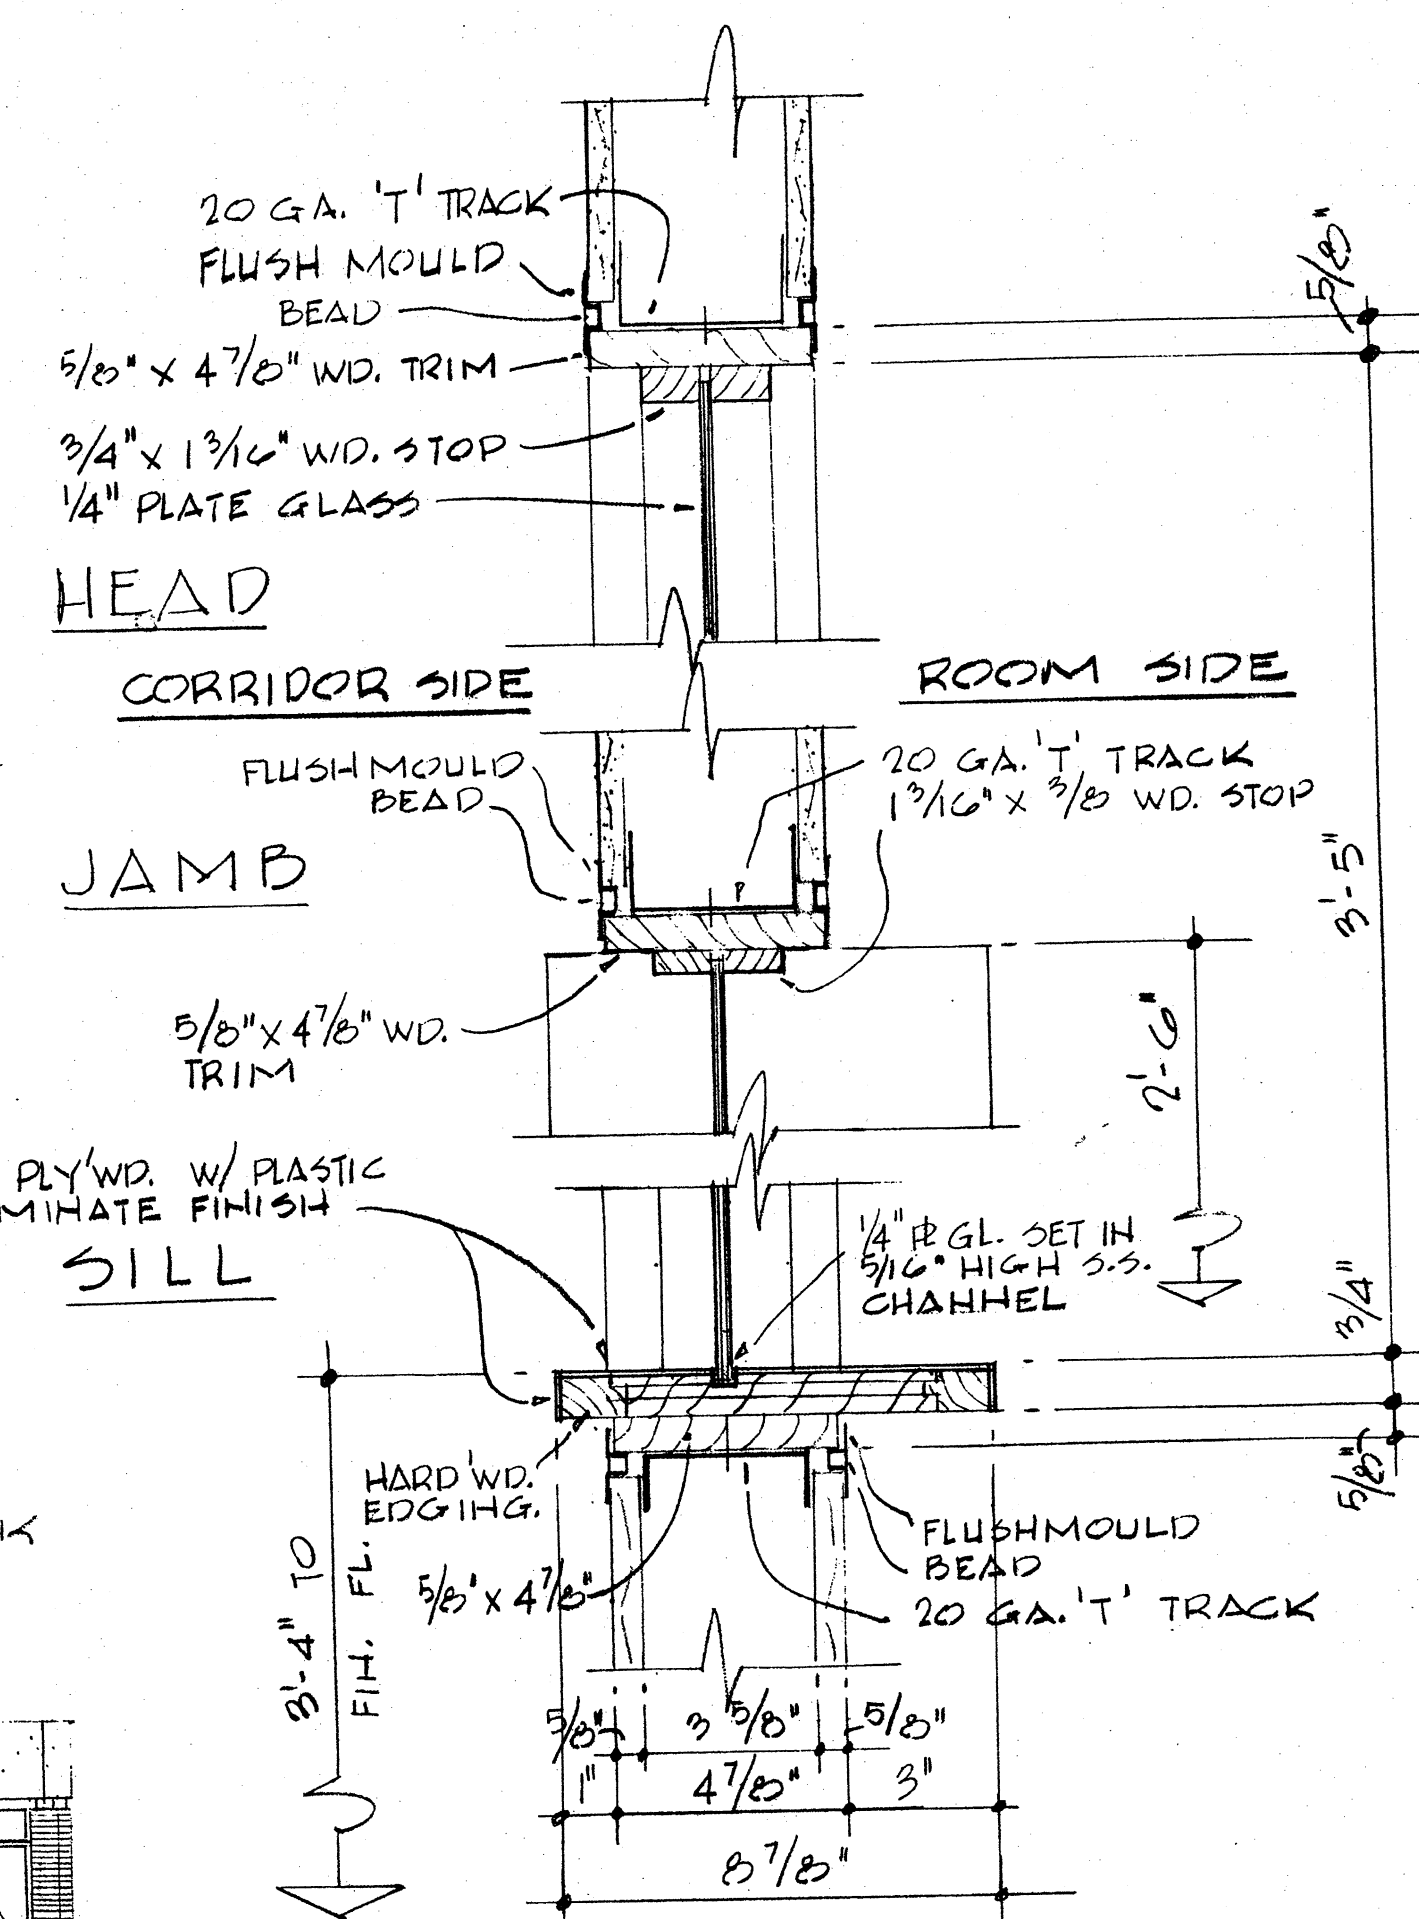

SECTION
SCALE: 3" = 1'-0"

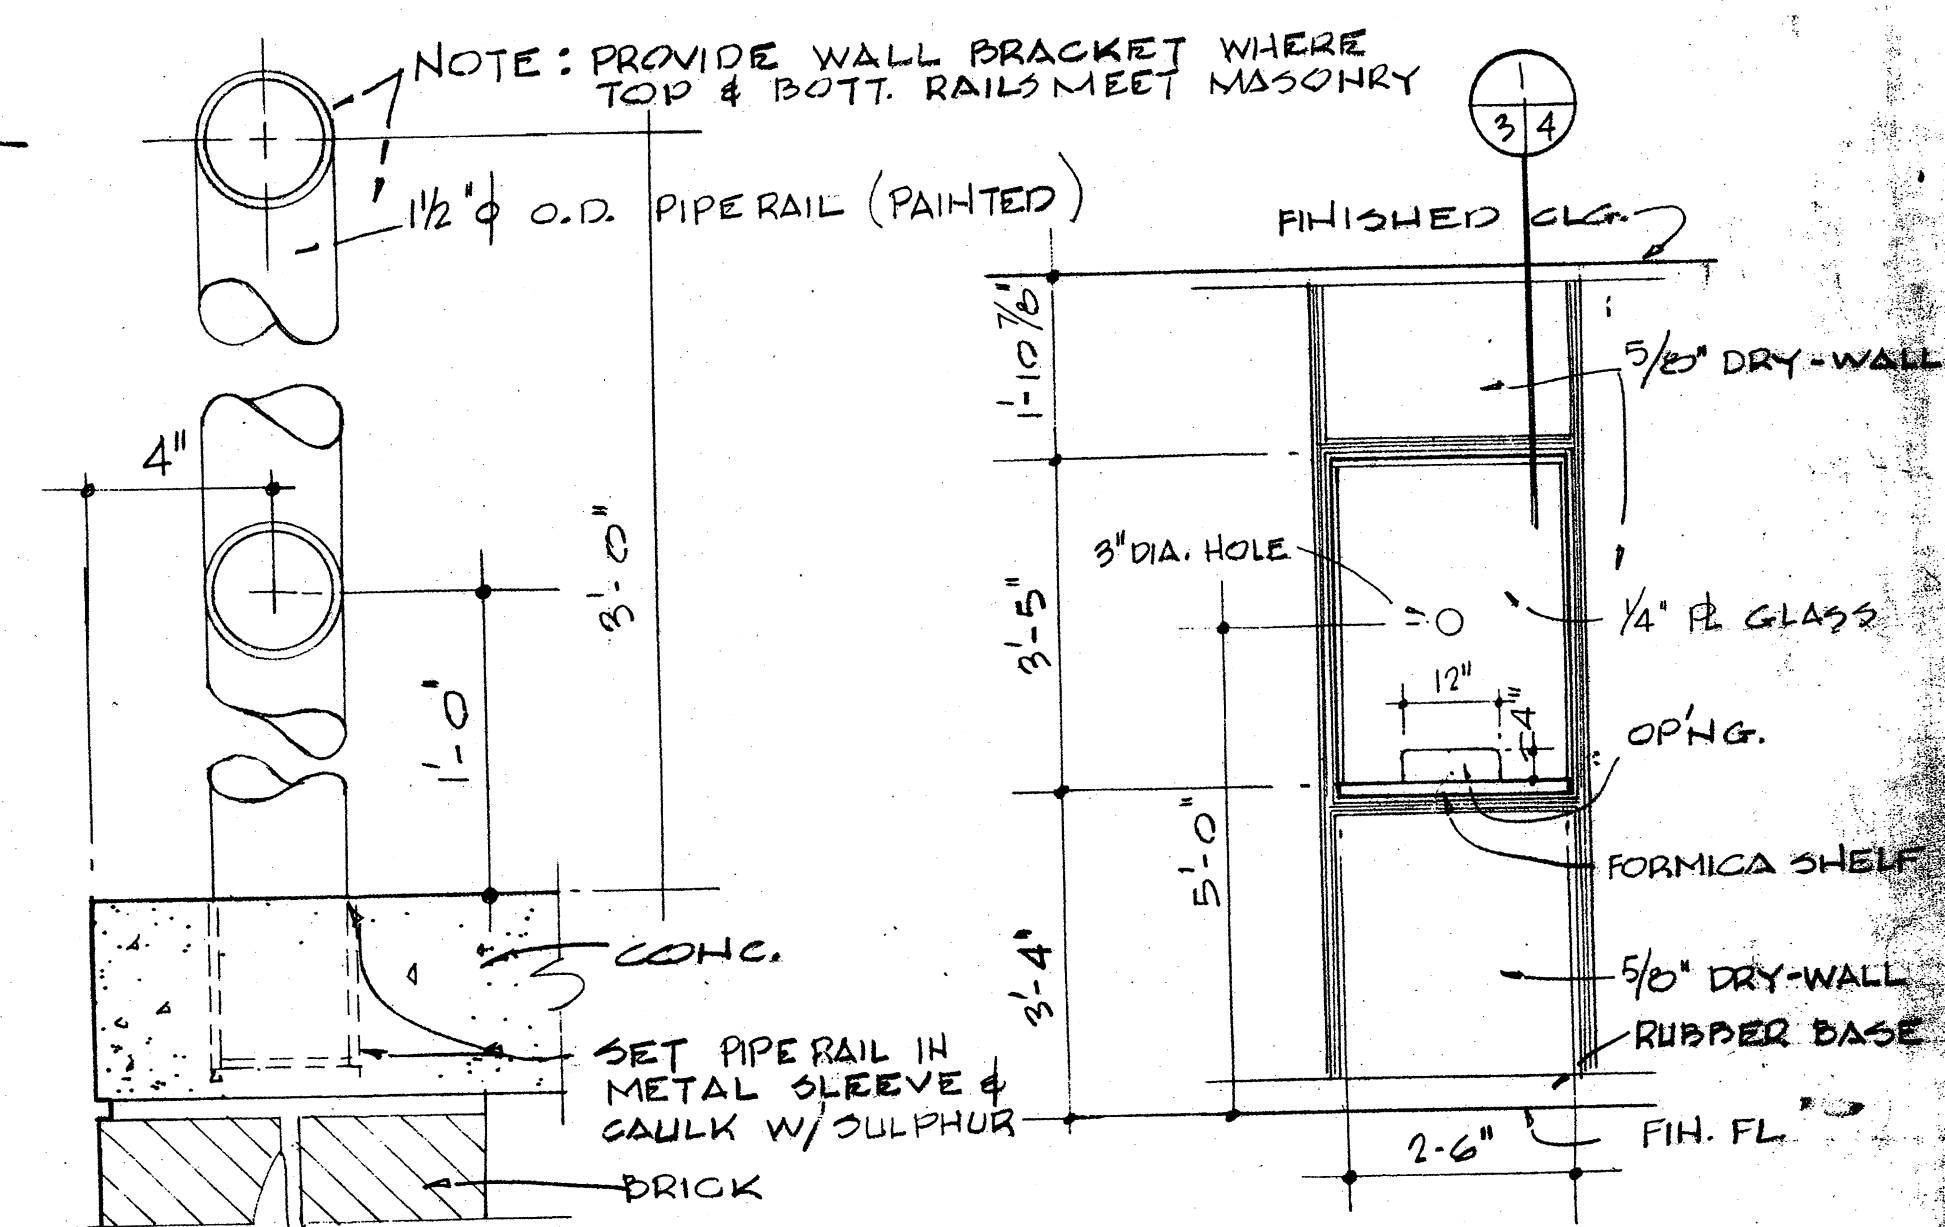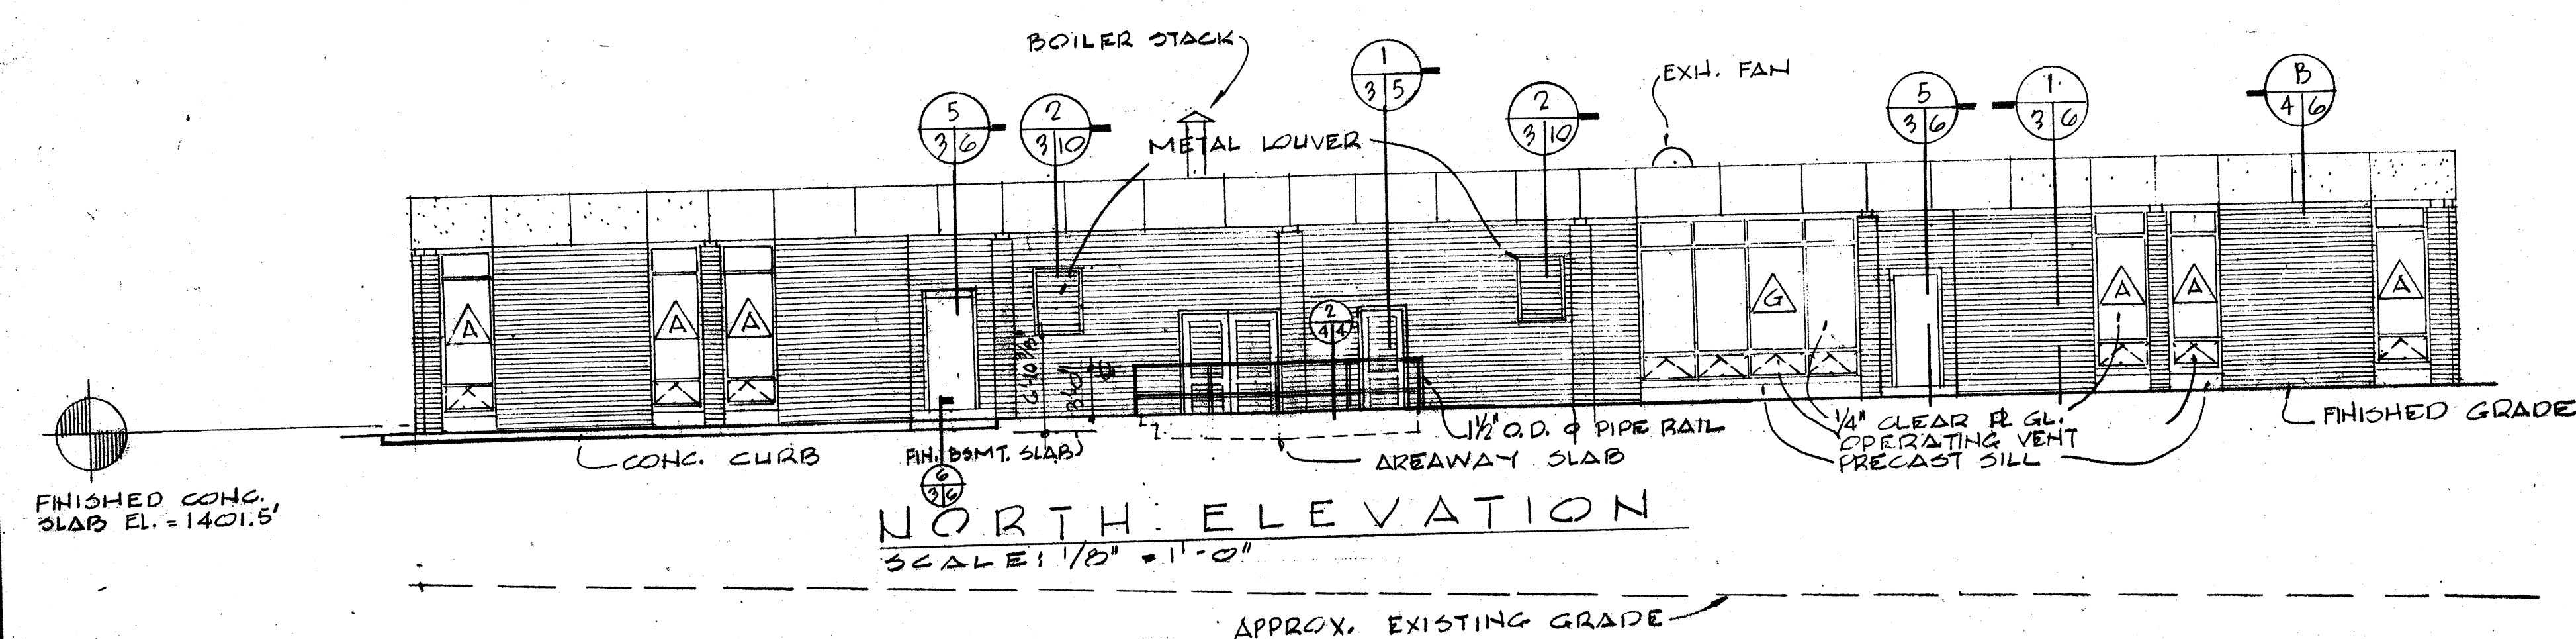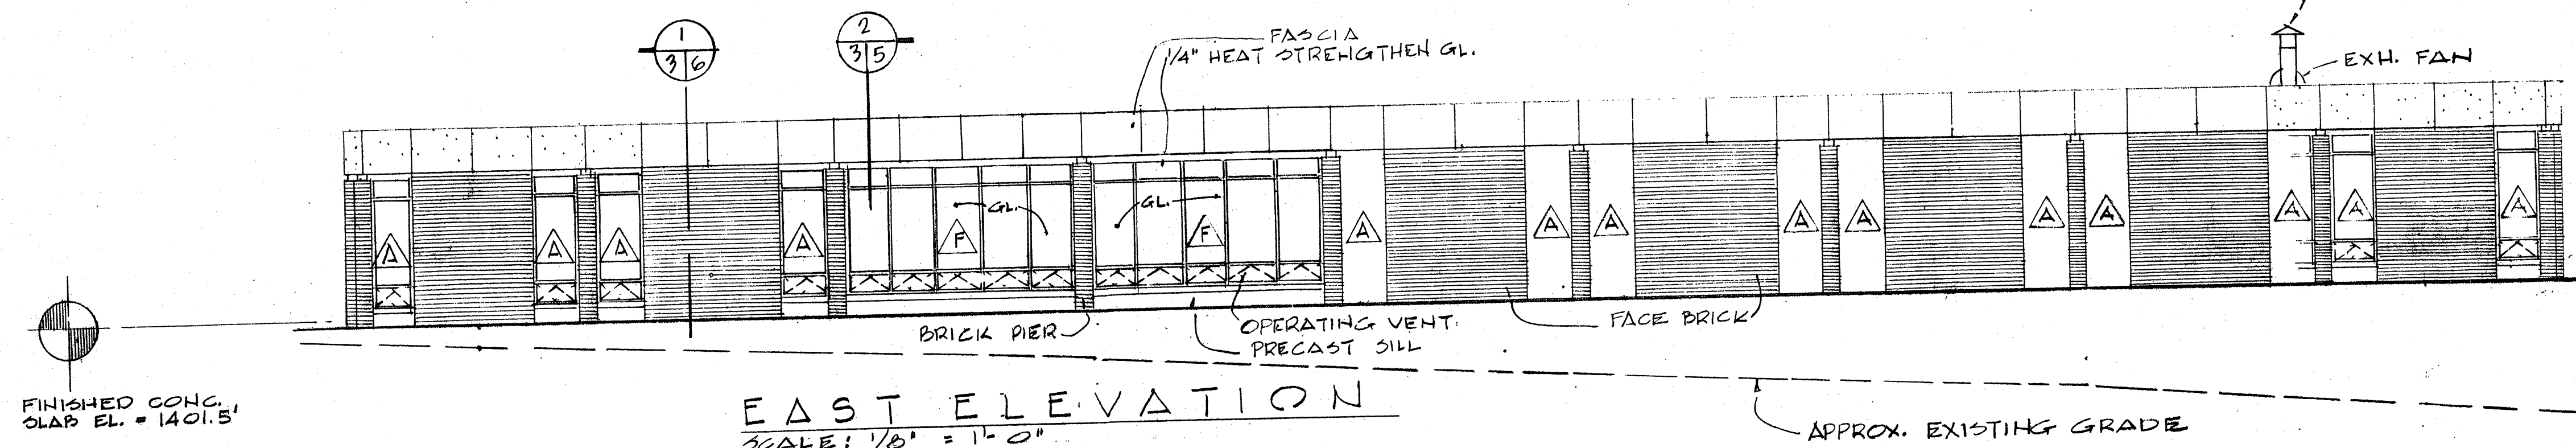

SECTION  ELEVATION of PASS-WIN.
SCALE: 3" = 1'-0" SCALE: 3" = 1'-0"
"AS BUILT DWGS" 8-28-73

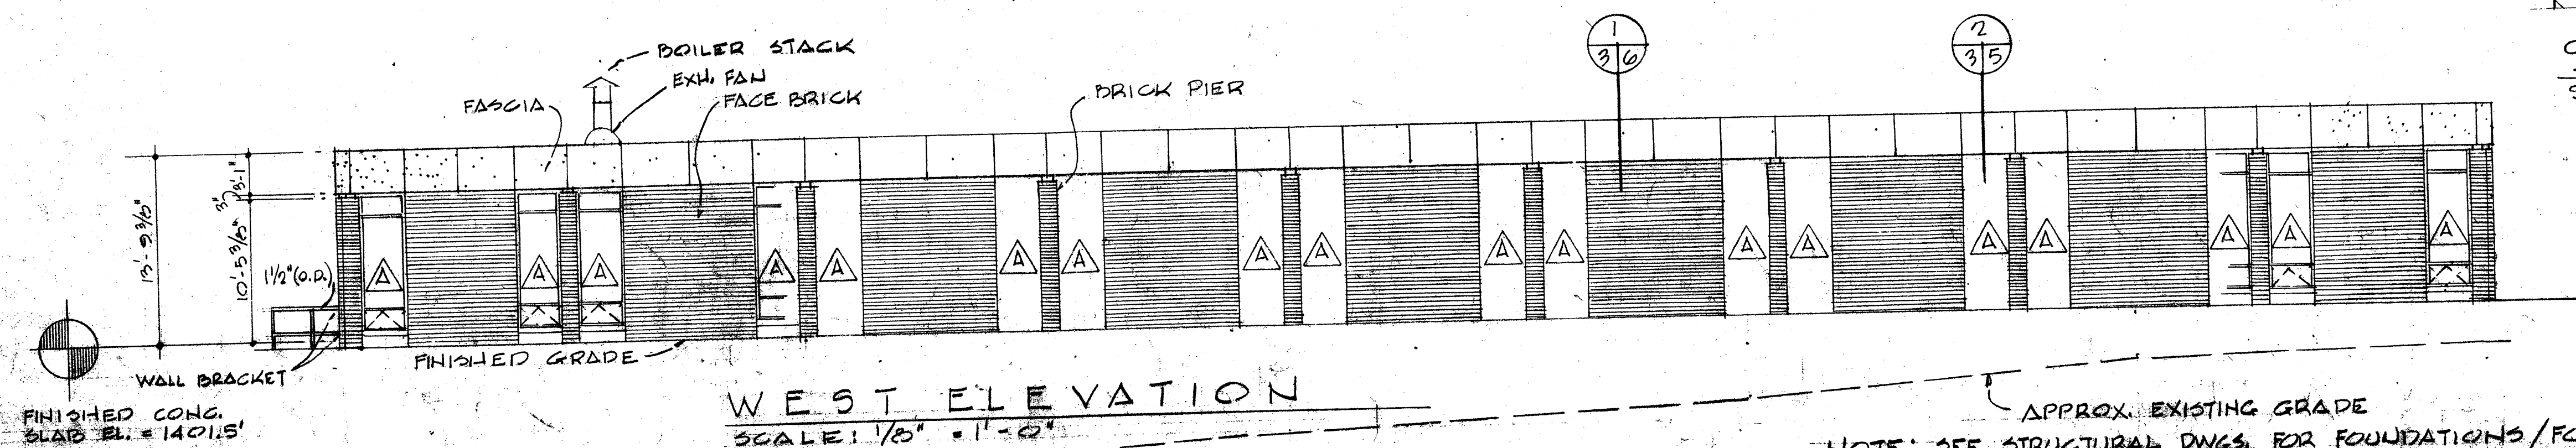

ADMINISTRATION BUILDING WESTERN STATE HOSPITAL (NEW SITE)			STAUNTON VIRGINIA
 COMMONWEALTH OF VIRGINIA Marcellus E. Wright, Jr. CERT. NO. 392 CERTIFIED ARCHITECT	REVISIONS	MARCELLUS WRIGHT & PARTNERS ARCHITECTS	SHEET 1
	A & E NO. 6808		4 OF
	SHEET TITLE	CROZET HOUSE 100 E. MAIN STREET RICHMOND, VIRGINIA 23219	
BUILDING ELEVATIONS - 1/8" = 1'-0"			

	COLD WATER		PIPE GUIDE
	GATE VALVE		UNION
	CHECK VALVE		THERMOMETER
	STRAIGHT		THEATRICAL
	PLUG VALVE		ECCENTRIC REDUCER
	AUTOMATIC VALVES		
	HOT WATER		
	HOT WATER HEATING		
	DIRECTION OF FLOW IN PIPE		
	PRESSURE REDUCING VALVE (PRV)		
	PIPE TURNING UP		
	PIPE TURNING DOWN		
	R.V. or R.V. RELIEF VALVE		
	REFRIGERANT SUC.		
	REFRIGERANT LIQUID		
	PRESSURE GAUGE ASSEMBLY		
	SQUARE PIPE		
	ARROW		
	DOWN FLOW		
	SUPPLY BODY SECTION		
	RETURN EXHAUST OR OUTLET		
	SIZE IN INCHES		
	SIZE IN FEET		
	RETURN OF SUPPLY GRILLE OR REGISTER		
	C.D. CEILING DIFFUSER		
	PATTERN AS INDICATED		
	CEILING EXHAUST OR RETURN AIR GRILLE OR REGISTER		
	FLEXIBLE CONNECTION		
	SQUARE ELBOW WITH MULTIPLE TURNING VANES		
	MANUAL DAMPER		
	MOTOR OPERATED DAMPER		
	ELBOW TURNING DOWN		
	DEFLECTOLE		

ACU	AIR CONDITIONING UNIT	CORR	CORRIDOR
AHU	AIR HANDLING UNIT	MBH	THOUSAND BTU
CD	CEILING DIFFUSER	CFM	CUBIC FEET PER MINUTE
ER	EXHAUST REGISTER	EXH	EXHAUST
GPM	GALLONS PER MINUTE	DO	DOOR GRILLE
OA	OUTSIDE AIR	NO	NORMALLY OPENED
RA	RETURN AIR	NC	NORMALLY CLOSED
RR	RETURN REGISTER	EQT	EQUIPMENT
UH	UNIT HEATER	DA	DIRECT ACTING
HW	HOT WATER	ME	MECHANICAL EQUIPMENT
BB RAD	BASEBOARD RADIATION	REQD	REQUIRED
EWI	ENTERING WATER TEMPERATURE	TSTAT	THERMOSTAT
TY	TYPICAL	GA	GAUGE
EA	EACH	SR	SUPPLY REGISTER
RL	REFRIGERANT LIQUID		
HG	REFRIGERANT HOT GAS		

WILEY & WILSON
ENGINEERS · ARCHITECTS · PLANNERS
LYNCHBURG, VIRGINIA

ADMINISTRATION BUILDING
WESTERN STATE HOSPITAL (NEW SITE)


STAUNTON

**MARCELLUS WRIGHT & PARTNERS
ARCHITECTS**

**CROZET HOUSE 100 E. MAIN STREET
RICHMOND, VIRGINIA 23219**

SHEET NO.
M-1
OF 4
DATE
JULY, 1970

PLAN - HTG. & AIR COND.

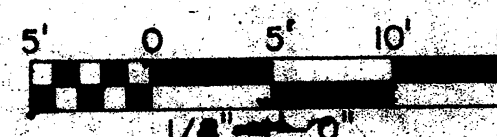

SCALE: 1/8" = 1'-0"

COOLING:	
SENSIBLE	612,744 BTUH
LATENT	33,193
VENTILATION	<u>186,508</u>
TOTAL	832,005 BTUH




HEATING

LEGEND PLUMBING


- SANITARY SOIL & WASTE
- - - SANITARY VENT
- PIPE TURNING UP
- PIPE TURNING DOWN
- COLD WATER
- HOT WATER
- ⊥ FLOOR DRAIN AND TRAP
- DIRECTION OF FLOW IN PIPE
- STORM DRAINS
- ⊙ POINT OF CONNECTION, NEW WORK TO EXISTING WORK
- ⊙ FH FIRE HYDRANT

ABBREVIATIONS


- | | |
|--------|-------------------------|
| CO | CLEAN OUT |
| FD | FLOOR DRAIN |
| W | SANITARY SOIL OR WASTE |
| VTR | VENT THRU ROOF |
| WV | SANITARY WASTE AND VENT |
| FCO | FLOOR CLEAN OUT |
| INVEL. | INVERT ELEVATION |
| MH | MANHOLE |
| DS | DOWNSPOUT |
| CB | CATCH BASIN |

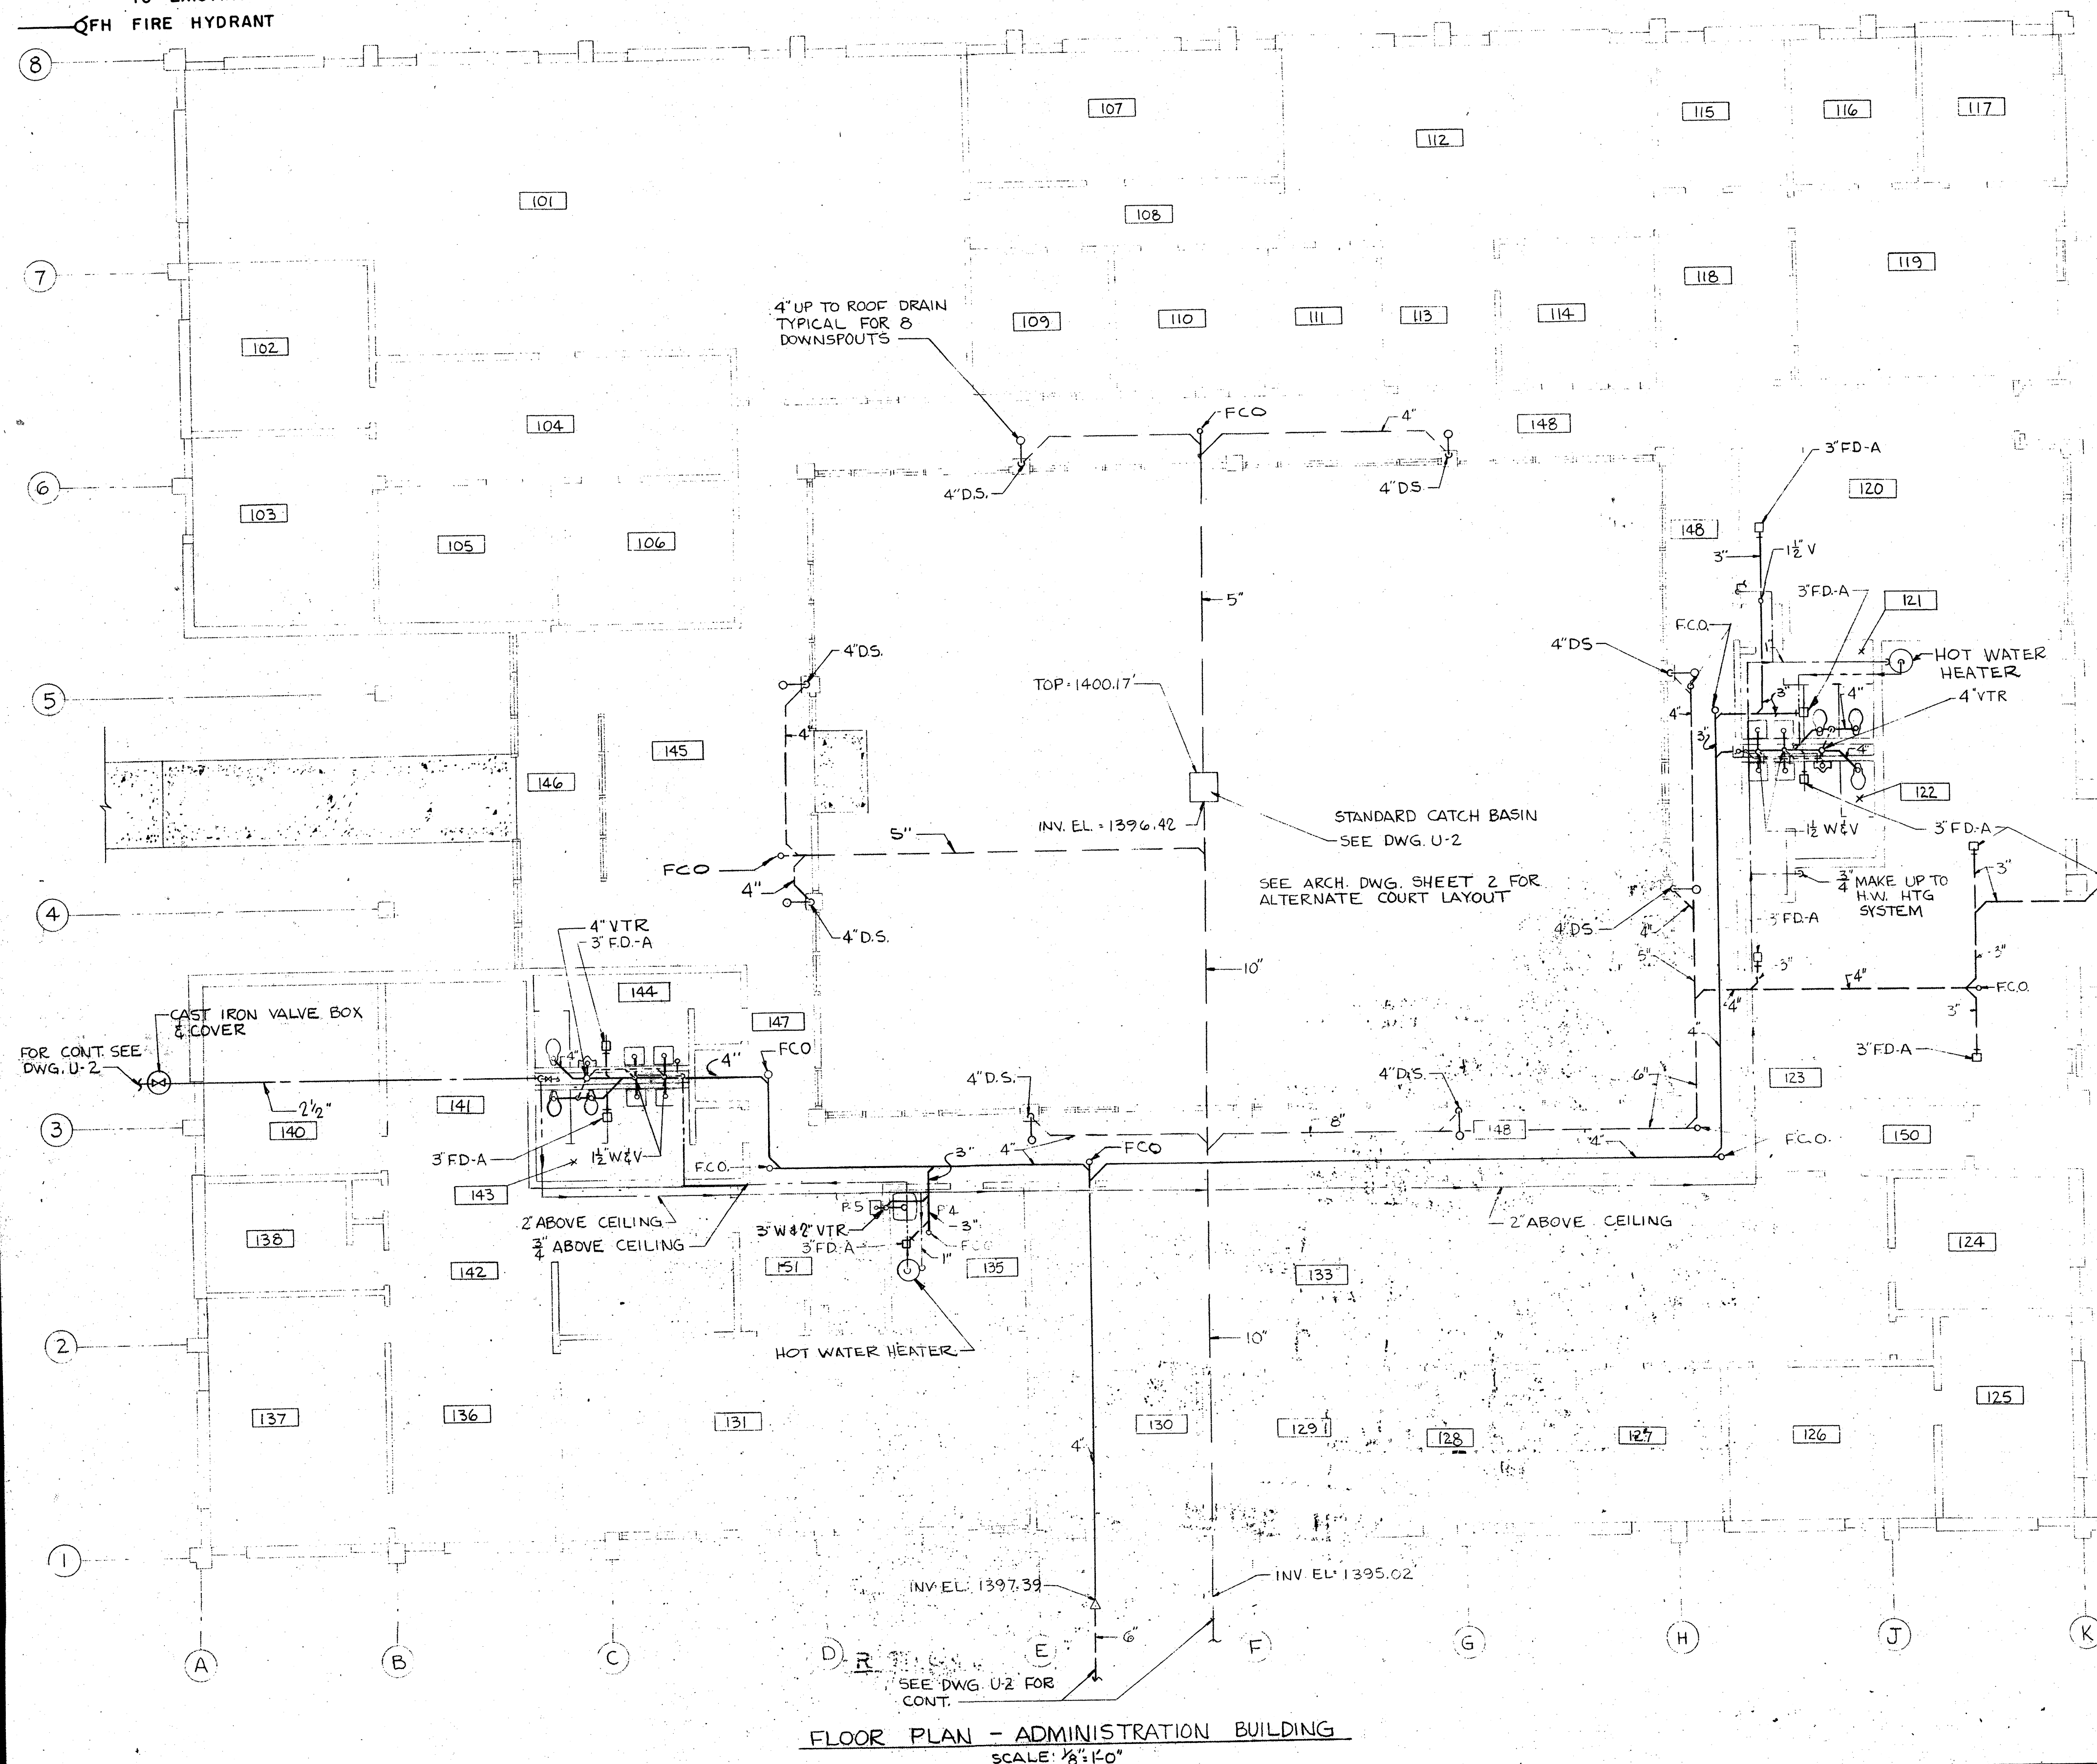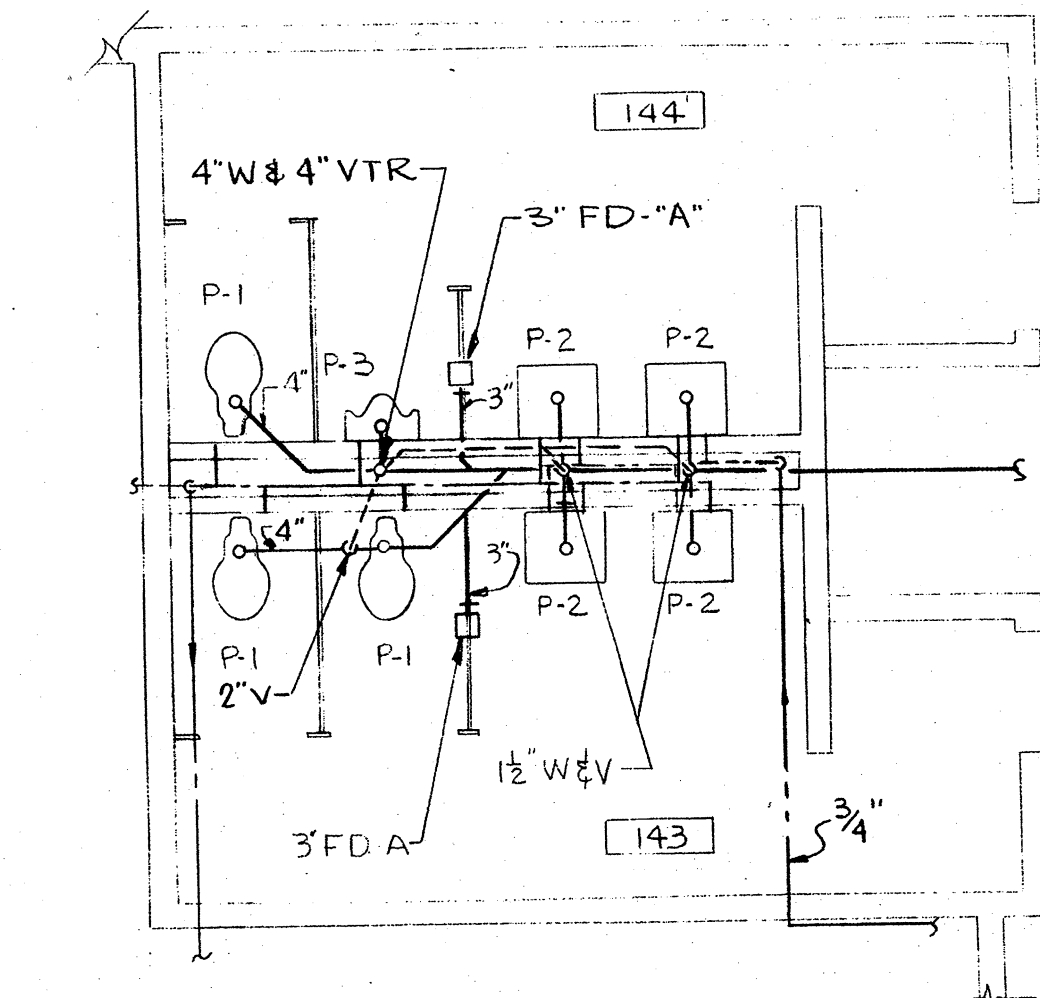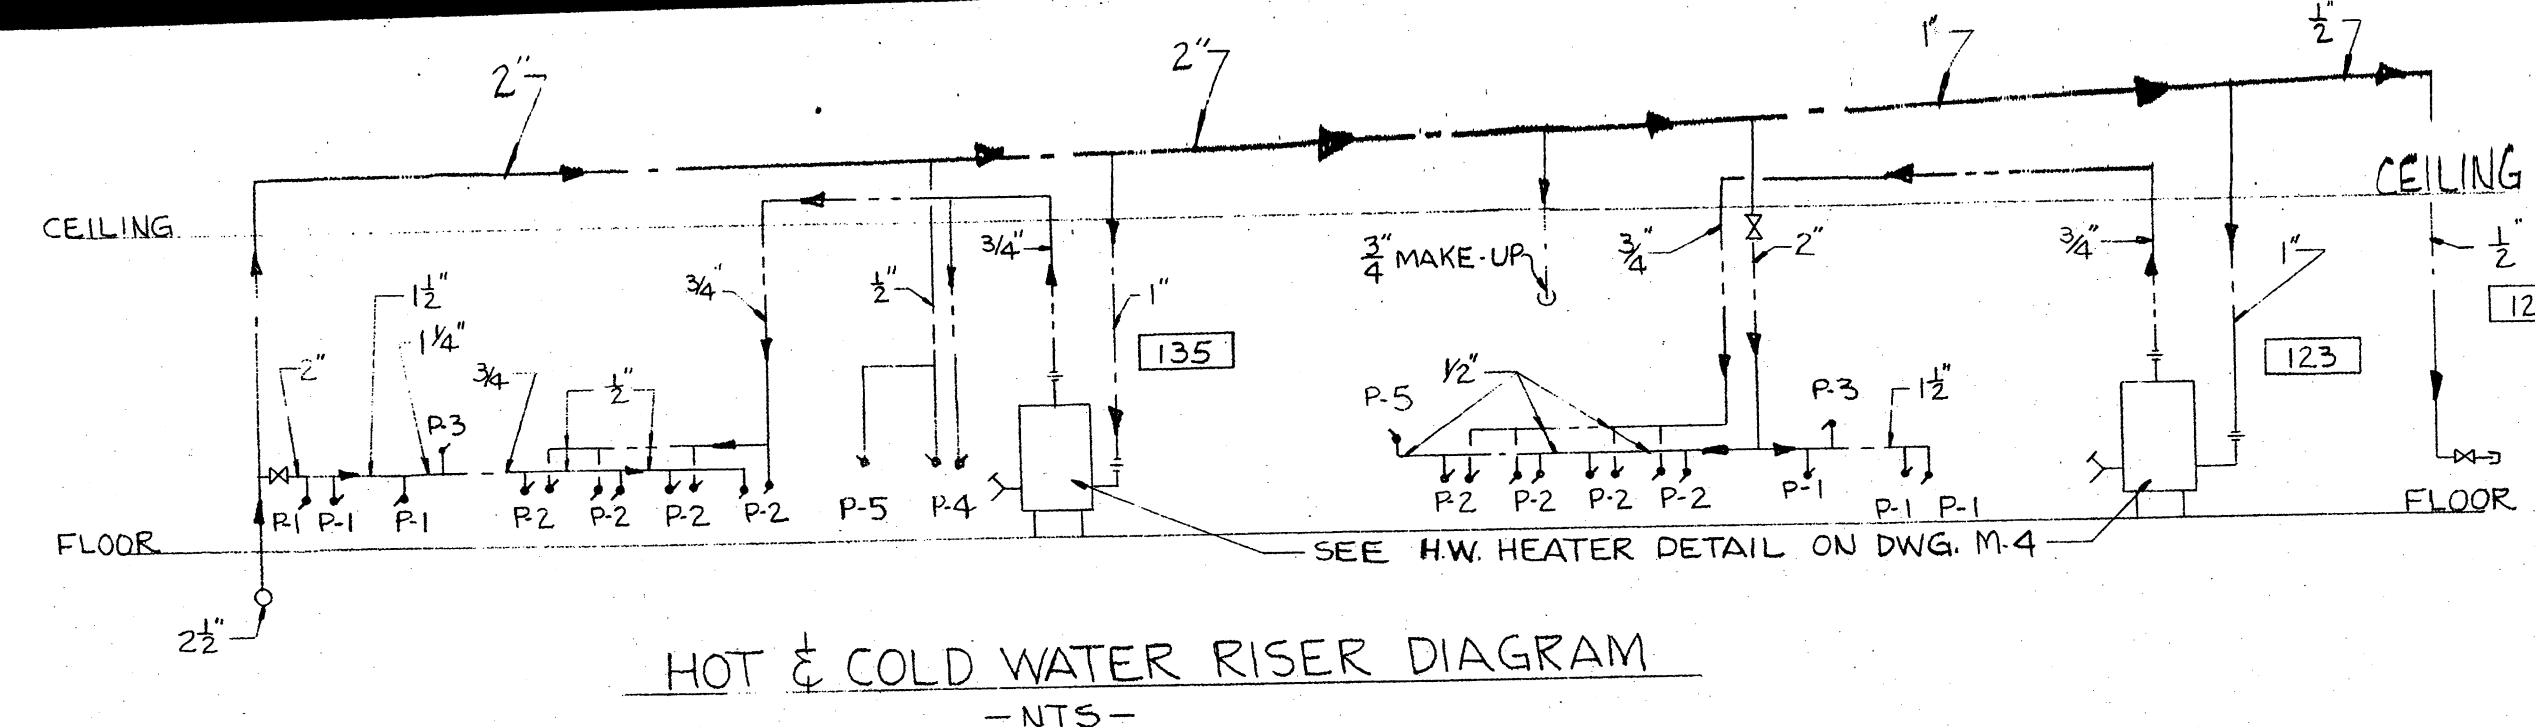

PARTIAL PLAN OF TOILETS - 143 & 144
SCALE: 1/4" = 1'-0"

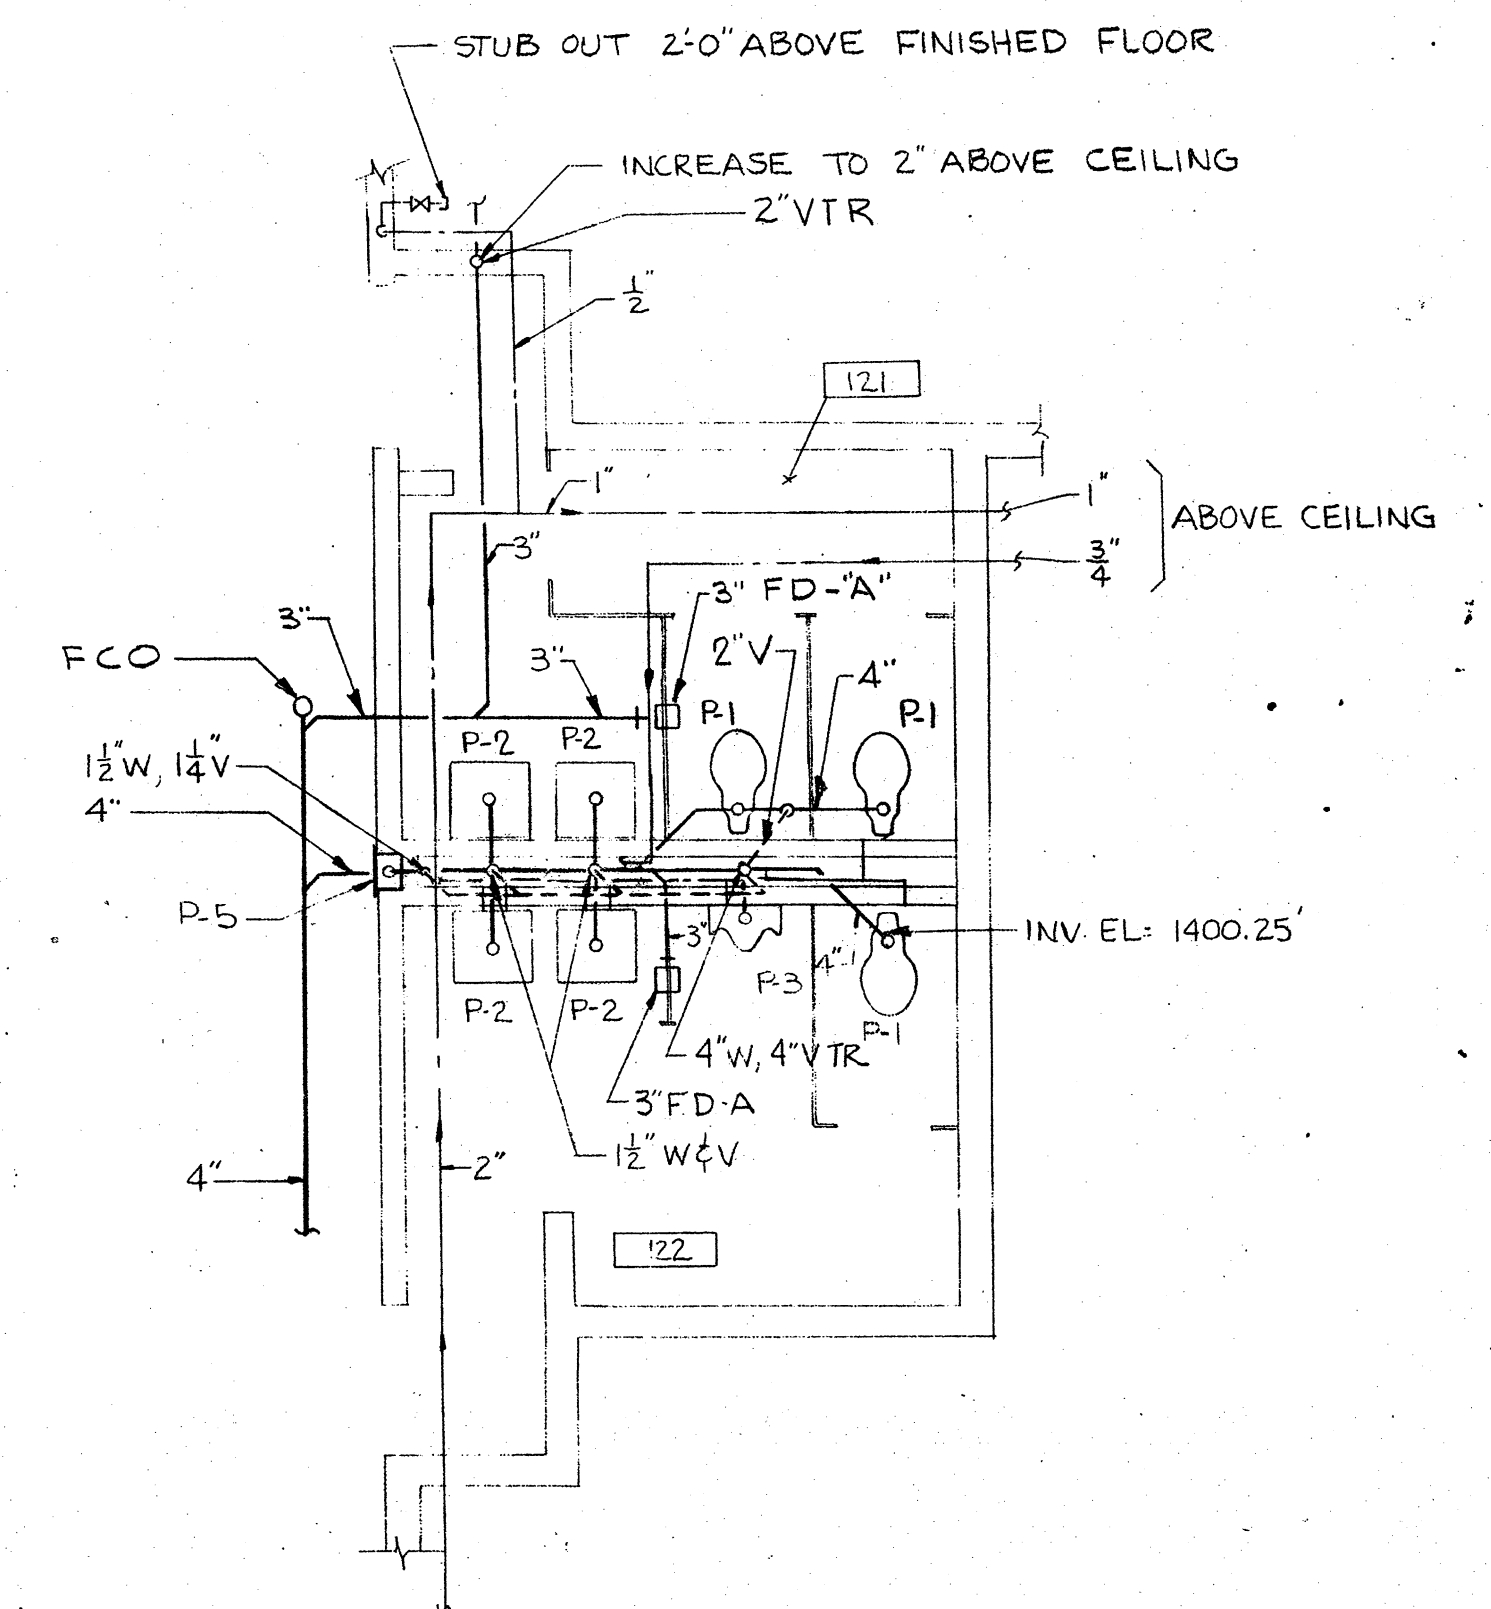

GRAPHIC SCALES

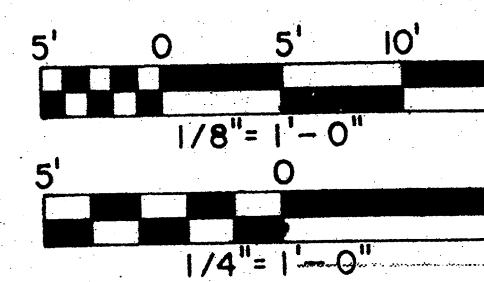

PARTIAL PLAN OF TOILETS - 121 & 122
SCALE: 1/4" = 1'-0"

"AJ BUILT DWG'S" 12-4-73

WILEY & WILSON ENGINEERS - ARCHITECTS - PLANNERS LYNCHBURG, VIRGINIA		ADMINISTRATION BUILDING WESTERN STATE HOSPITAL (NEW SITE) STAUNTON, VIRGINIA	
		REVISIONS A & E NO. 9030	MARCELLUS WRIGHT & PARTNERS ARCHITECTS CROZET HOUSE 100 E. MAIN STREET RICHMOND, VIRGINIA 23219
		SHEET NO. M-3 OF 4 DATE JULY, 1970	
SHEET TITLE PLAN - PLUMBING			